
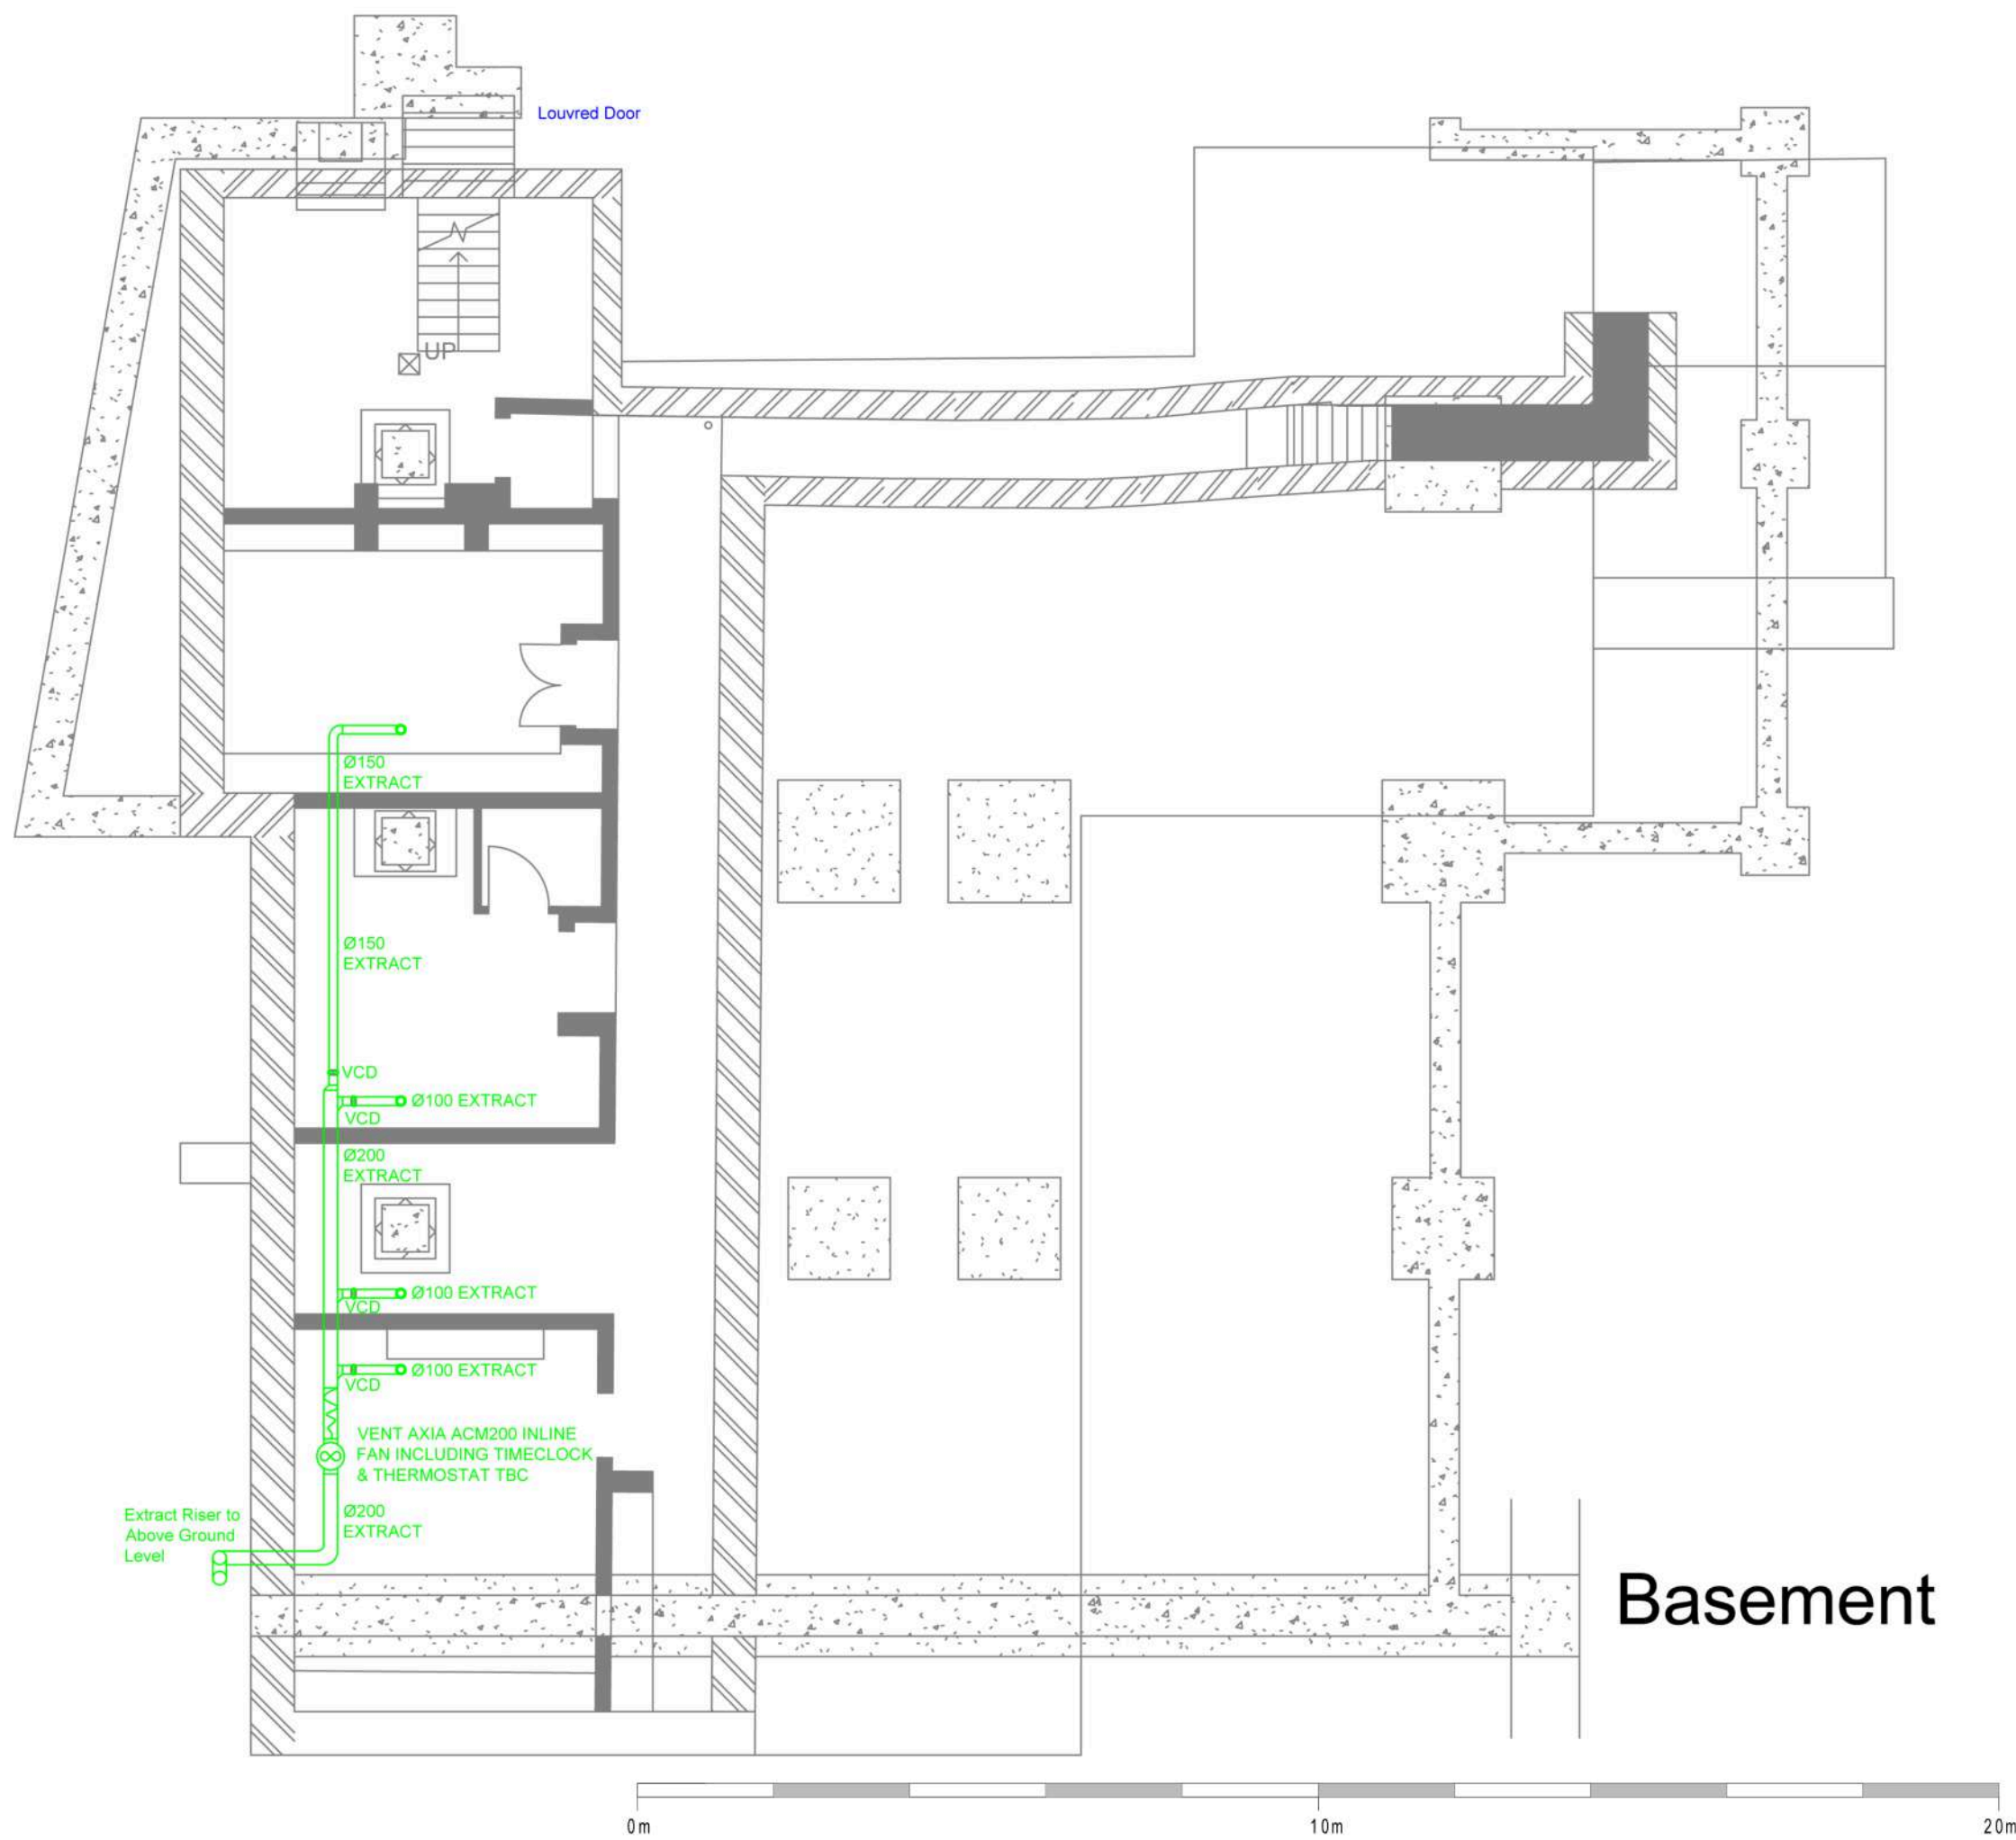
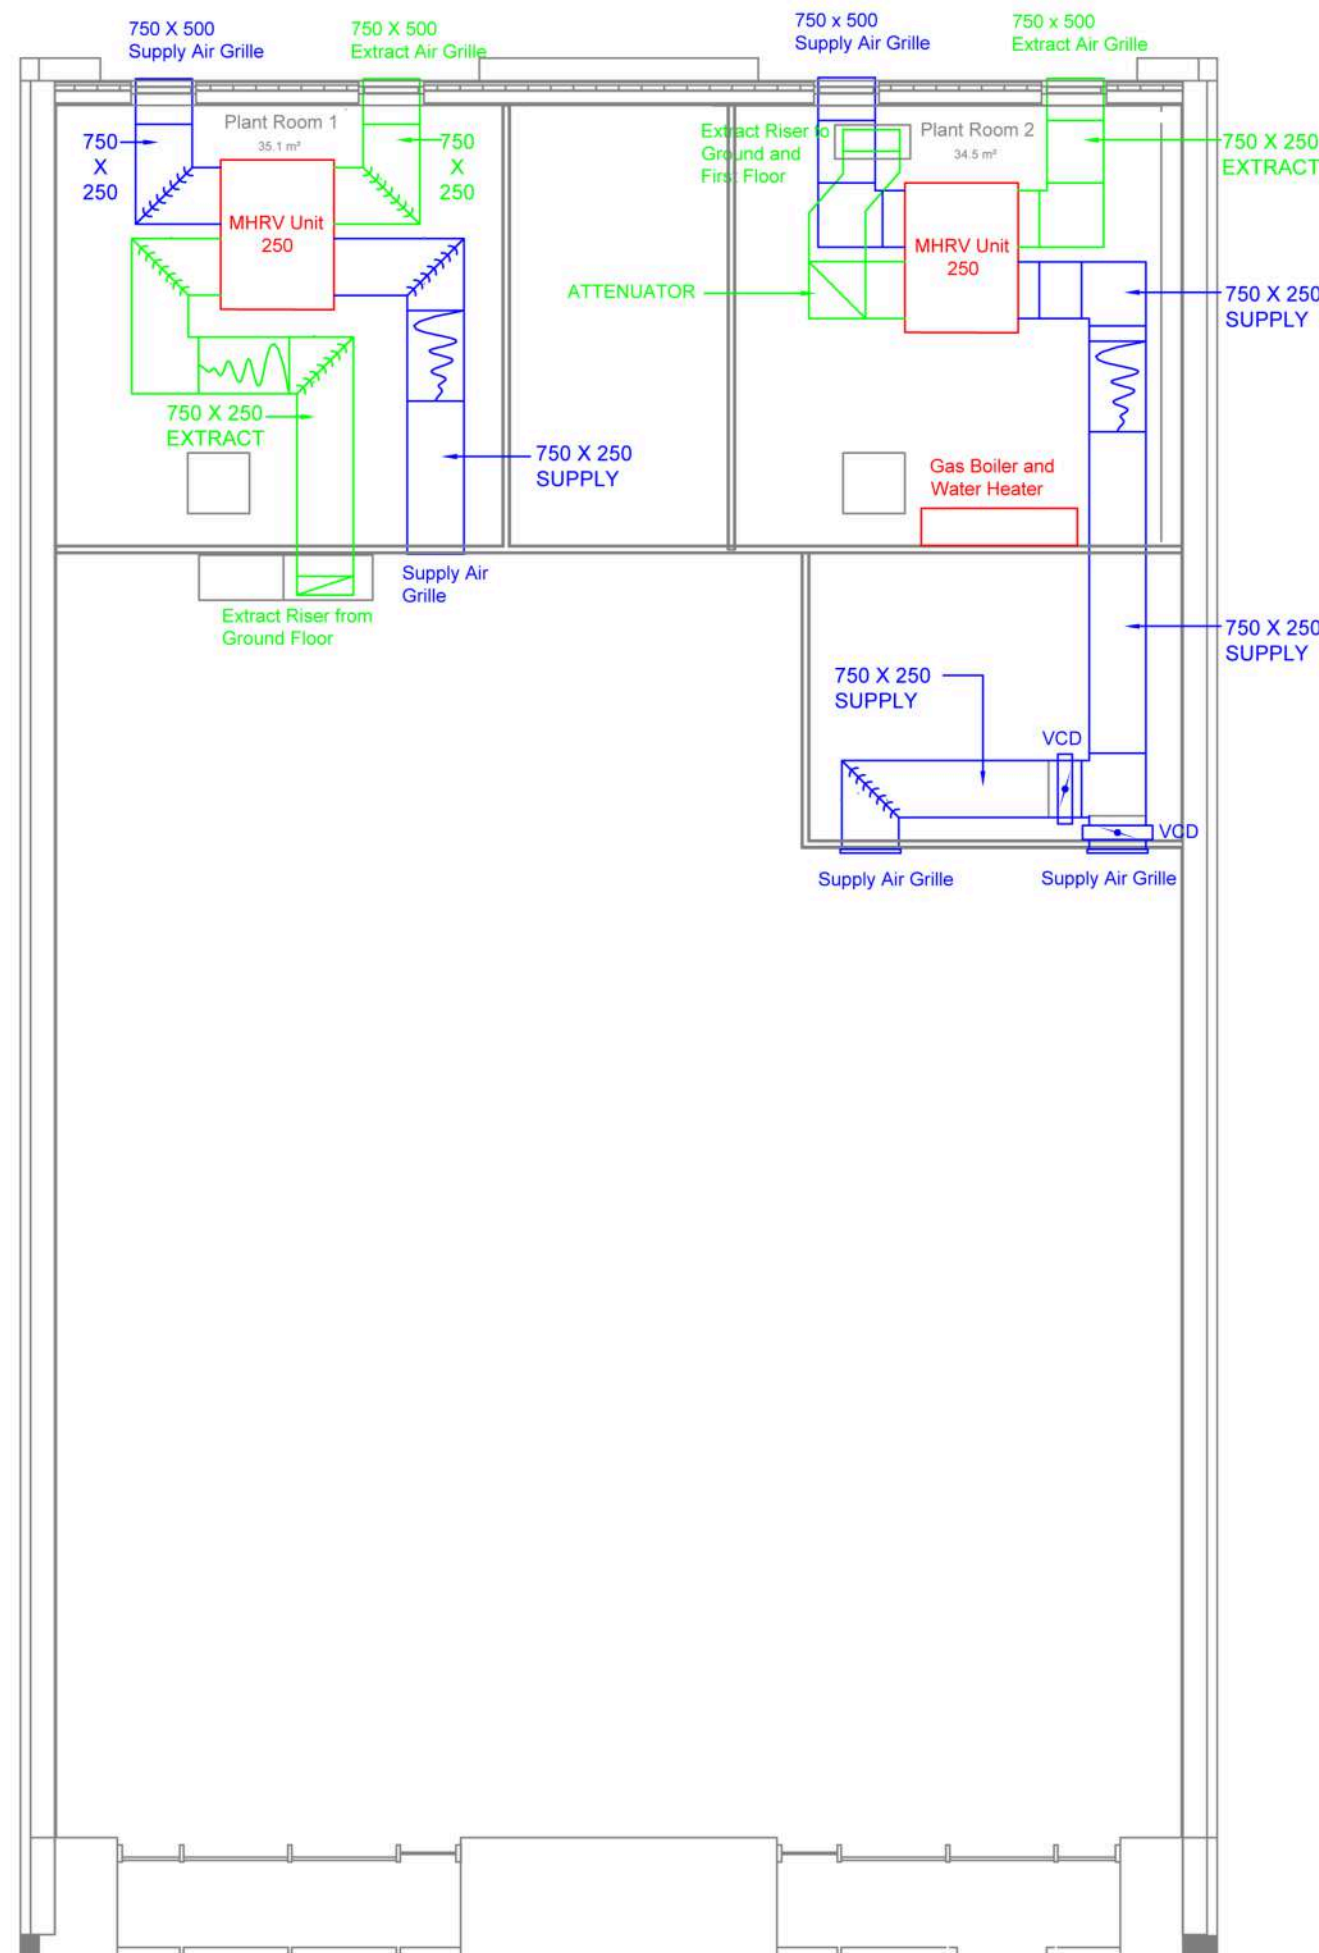
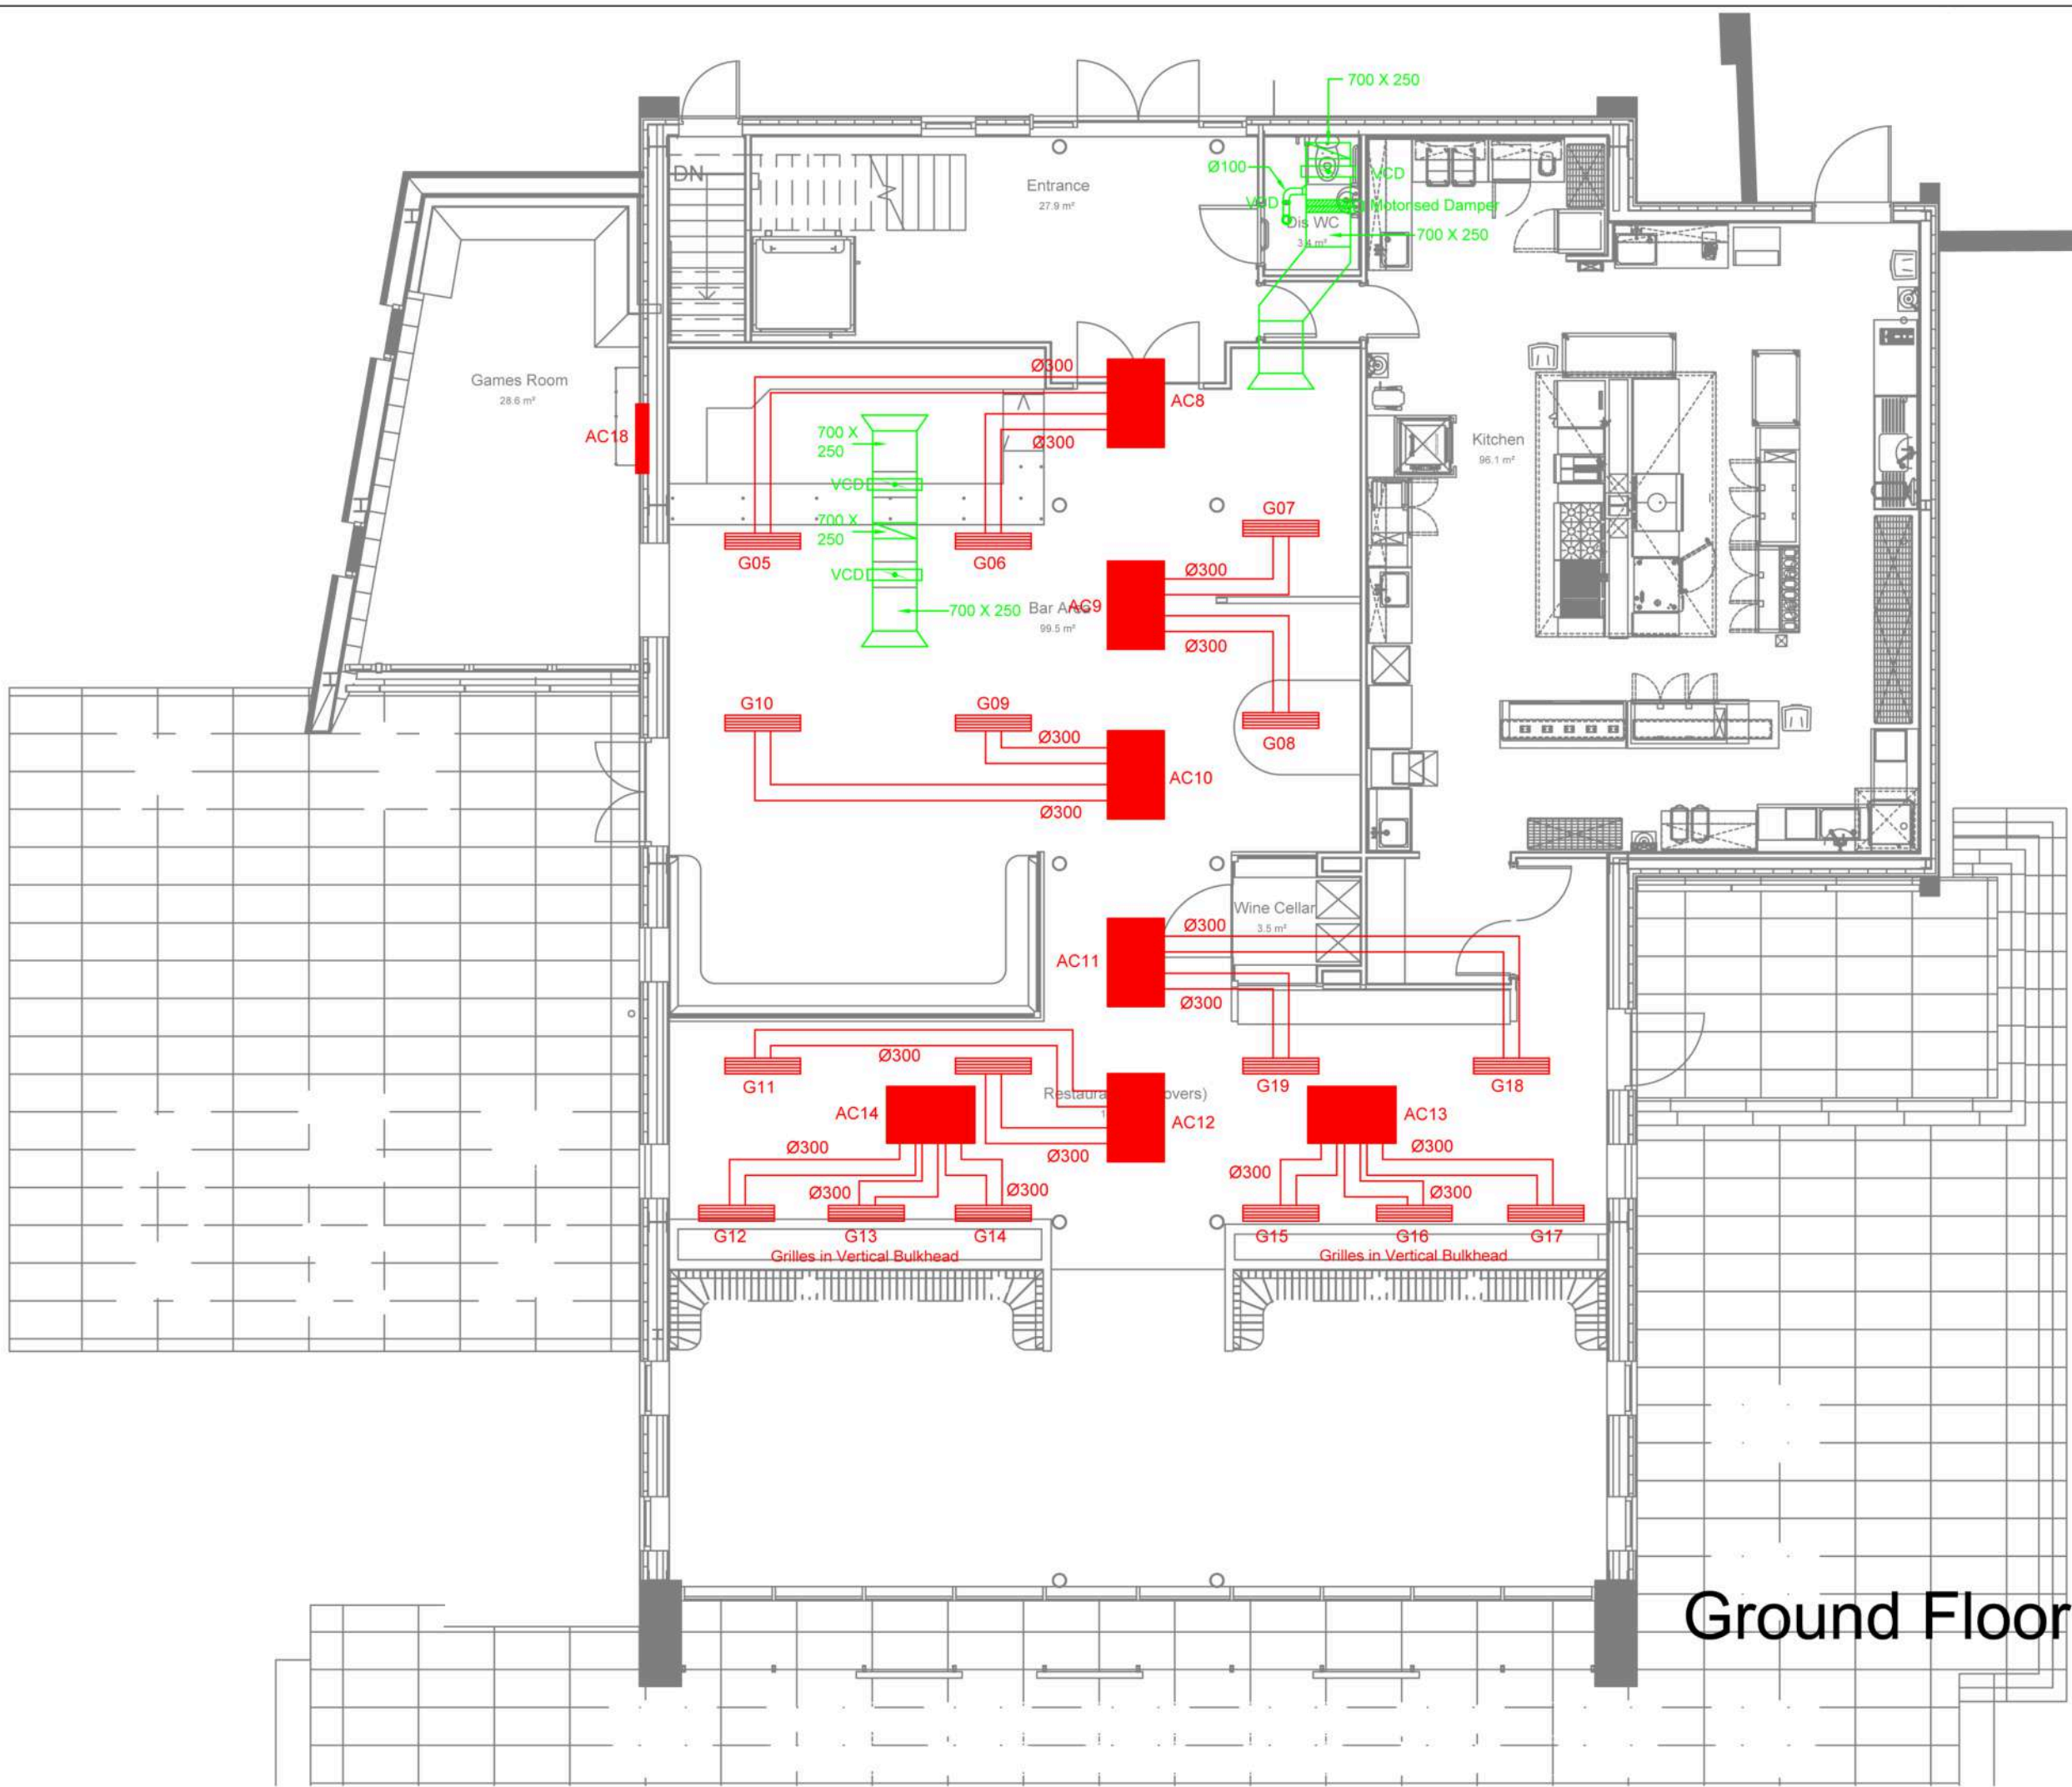


SCHEDULE 1	
REF	MITSUBISHI MODEL
AC1	VRF PFFY-M50VCM
AC2	VRF PFFY-M50VCM
AC3	VRF PFFY-M50VCM
AC4	VRF PFFY-M50VCM
AC5	VRF PFFY-M50VCM
AC6	PUZ-ZM50VKA
AC7	VRF-PFFY-M50VCM
AC8	VRF-PEFY-M63VMA
AC9	VRF-PEFY-M63VMA
AC10	VRF-PEFY-M63VMA
AC11	VRF-PEFY-M63VMA
AC12	VRF-PEFY-M63VMA
AC13	VRF-PEFY-M63VMA
AC14	VRF-PEFY-M63VMA
AC15	VRF-PEFY-M63VMA

SCHEDULE 2	
REF	TYPE
G01	TBC
G02	TBC
G03	TBC
G04	TBC
G05	TBC
G06	TBC
G07	TBC
G08	TBC
G09	TBC
G10	TBC
G11	TBC
G12	TBC
G13	TBC
G14	TBC
G15	TBC
G16	TBC
G17	TBC
G18	TBC
G19	TBC
G20	TBC
G21	TBC
G22	TBC

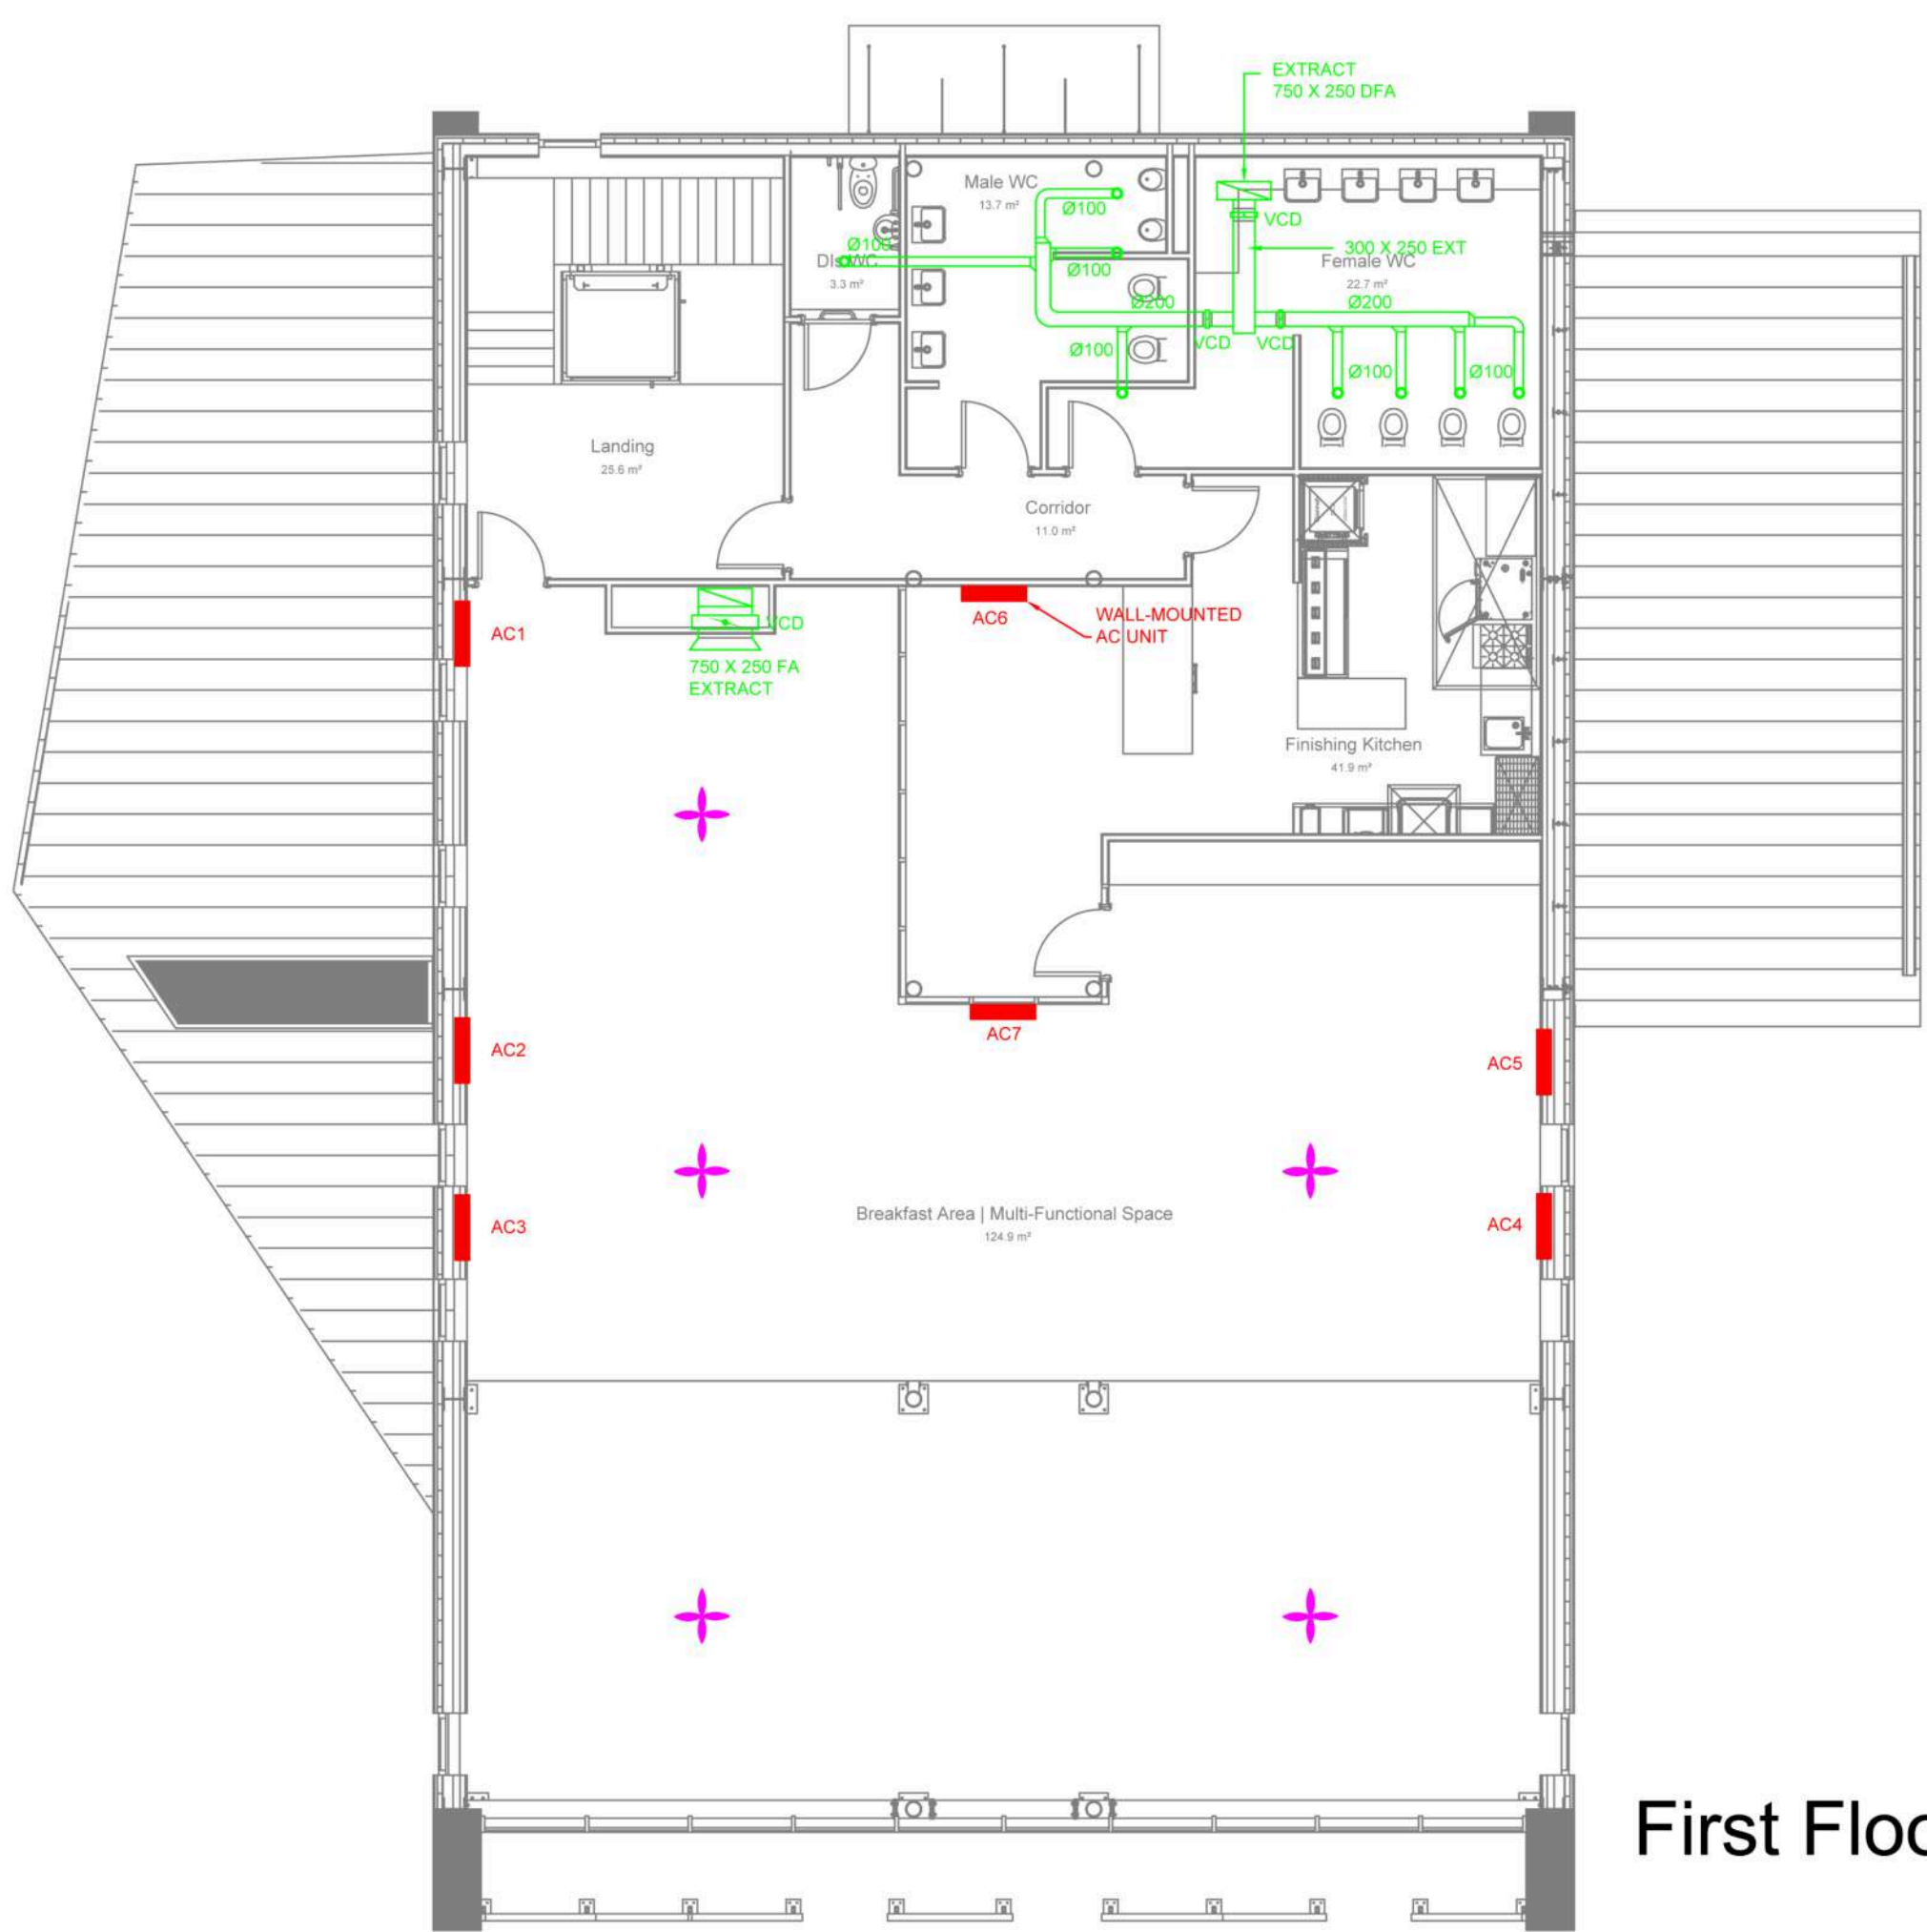

- LEGEND:
- ✚ Destratification Fan
 - Ceiling Concealed Ducted AC Unit
 - Linear Air Supply Grille
 - ⌋ Recessed Floor Standing Concealed AC Unit
 - Linear Extract Grille
 - Extract Duct Riser
 - Extract Air Valve
 - VCD

B	AC6 AND AC7	25/02/21
A	XREF UPDATED	08/02/21
REV	DESCRIPTION	DATE

PROPOSED



Higgins Lab Chem Plumbing Limited
The Depot, Station Street
Macclesfield, Cheshire
SK10 2AW

T: 01625 613308

W: www.higginsonline.co.uk

CLIENT:

PROJECT:
CONSALL HALL ESTATE
CONSALL
NR LEEK

DRAWING TITLE:
HUB BUILDING
MECHANICAL LAYOUT

SCALE: 1:100 AT A1	DRAWN: JB CHECKED: CG	DATE: 03/02/21 DATE: 03/02/21
DRAWING NUMBER: HLCP-CH-HUB-M100	REVISION: B	SHEET: 1 OF 1