

NOTES

|                      |          |
|----------------------|----------|
| NOMINATION FORM DATE | 22/10/20 |
| NOMINATION REVISION  | v5.0     |
| T-MOBILE CELL ID     | 26762    |

PROJECT No. 226130

CELL No. STM015

BT SKYLINE No. ST0032

| PROJ No | 226130                        |                  |
|---------|-------------------------------|------------------|
| 11      | PLANNING ISSUE                | 01/02/21 HFC LBG |
| 10      | PROJ No 171024 AS BUILT       | 06/11/17 DAL AN  |
| 9       | PROJ No 183975 AS BUILT       | 22/09/17 MON FC  |
| 8       | PROJ No 168110 AS BUILT AMEND | 30/05/17 HFC FC  |
| 7       | PROJ No 168110 AS BUILT       | 01/05/17 HFC KL  |
| ISS     | REVISION                      | DATE             |
| DRN     | APP                           |                  |



Crawley Court, Winchester, Hampshire, SO21 2QA  
Tel: 01962 822434, Fax: 01962 822378

SITE No 168001  
LEEK ATE  
ST EDWARDS STREET  
LEEK  
STAFFORDSHIRE  
ST13 5DQ

NGR SJ 98300 56490

OS GRID 398300 356490

TITLE  
SITE PLAN  
PROPOSED  
H3G & EE LTD


SCALE 1:200

DRAWN IM 19/08/11

APPROVED LBG 01/02/21

ORG No. Sheet 1 of 1 Rev

168001-02-100-MD011 11

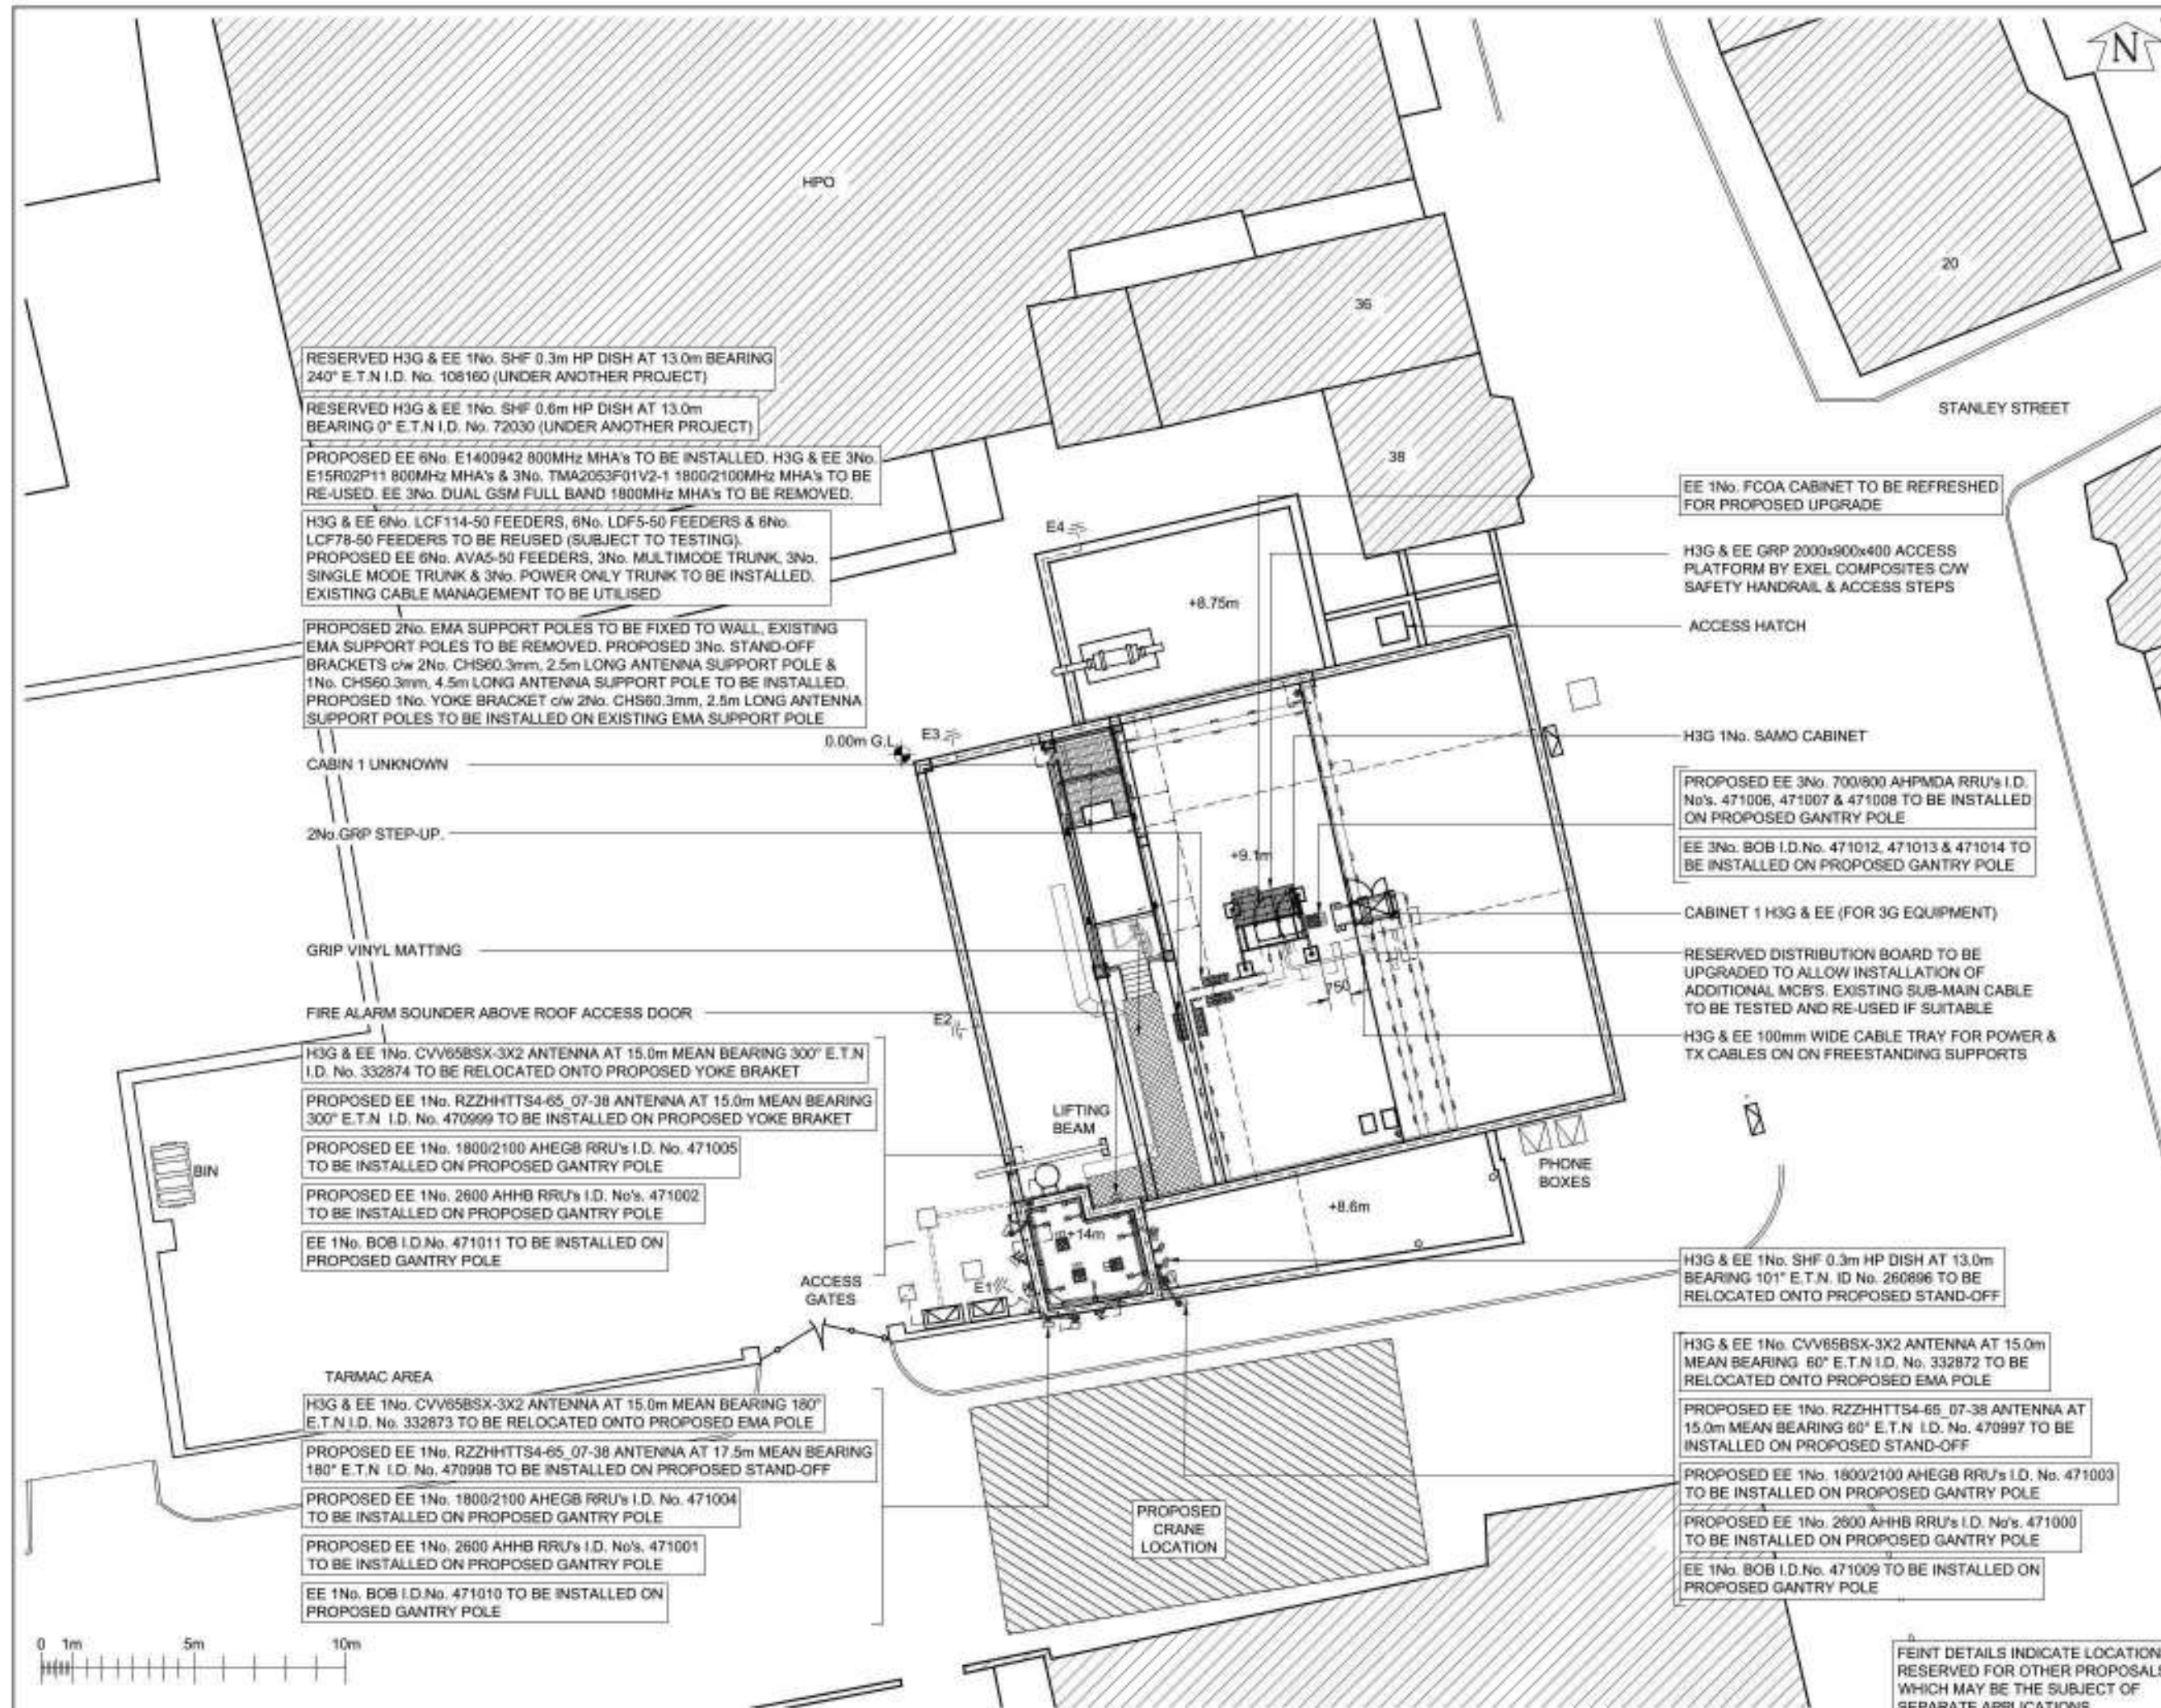

H3G & EE 1No. CVV6585X-3X2 ANTENNA AT 15.0m MEAN BEARING 180° E.T.N I.D. No. 332673 TO BE RELOCATED ONTO PROPOSED EMA POLE

PROPOSED EE 1No. RZZHHTTS4-65\_07-38 ANTENNA AT 17.5m MEAN BEARING 180° E.T.N I.D. No. 470998 TO BE INSTALLED ON PROPOSED STAND-OFF (BEHIND)

PROPOSED EE 1No. 1800/2100 AHEGB RRU's I.D. No. 471004 TO BE INSTALLED ON PROPOSED GANTRY POLE (BEHIND)

PROPOSED EE 1No. 2600 AHHB RRU's I.D. No's. 471001 TO BE INSTALLED ON PROPOSED GANTRY POLE (BEHIND)

EE 1No. BOB I.D.No. 471010 TO BE INSTALLED ON PROPOSED GANTRY POLE (BEHIND)

PROPOSED EE 1No. RD0725 HIGH LEVEL MHA's TO BE INSTALLED ON PROPOSED SUPPORT POLES

H3G & EE 1No. CVV6585X-3X2 ANTENNA AT 15.0m MEAN BEARING 60° E.T.N I.D. No. 332872 TO BE RELOCATED ONTO PROPOSED EMA POLE

PROPOSED EE 1No. RZZHHTTS4-65\_07-38 ANTENNA AT 15.0m MEAN BEARING 60° E.T.N I.D. No. 470997 TO BE INSTALLED ON PROPOSED STAND-OFF

PROPOSED EE 1No. 1800/2100 AHEGB RRU's I.D. No. 471003 TO BE INSTALLED ON PROPOSED GANTRY POLE

PROPOSED EE 1No. 2600 AHHB RRU's I.D. No's. 471000 TO BE INSTALLED ON PROPOSED GANTRY POLE

EE 1No. BOB I.D.No. 471009 TO BE INSTALLED ON PROPOSED GANTRY POLE

PROPOSED EE 1No. RD0725 HIGH LEVEL MHA's TO BE INSTALLED ON PROPOSED SUPPORT POLES

PROPOSED 1No. EMA POLE, 3No. STAND-OFF BRACKET C/W 3No. CHS60.3mm, 2.5m LONG SUPPORT POLES & 1No. YOKE BRACKET C/W 2No. CHS60.3mm, 2.5m LONG SUPPORT POLES

CTIL SHF 0.3m HP DISH D1 AT 16.0m BEARING 101° E.T.N. ID No. 395767

H3G & EE 1No. CVV6585X-3X2 ANTENNA AT 15.0m MEAN BEARING 300° E.T.N I.D. No. 332874 TO BE RELOCATED ONTO PROPOSED YOKE BRACKET (BEHIND)

PROPOSED EE 1No. RZZHHTTS4-65\_07-38 ANTENNA AT 15.0m MEAN BEARING 300° E.T.N I.D. No. 470999 TO BE INSTALLED ON PROPOSED YOKE BRACKET (BEHIND)

PROPOSED EE 1No. 1800/2100 AHEGB RRU's I.D. No. 471005 TO BE INSTALLED ON PROPOSED GANTRY POLE (BEHIND)

PROPOSED EE 1No. 2600 AHHB RRU's I.D. No's. 471002 TO BE INSTALLED ON PROPOSED GANTRY POLE (BEHIND)

EE 1No. BOB I.D.No. 471011 TO BE INSTALLED ON PROPOSED GANTRY POLE (BEHIND)

PROPOSED EE 1No. RD0725 HIGH LEVEL MHA's TO BE INSTALLED ON PROPOSED SUPPORT POLES

PROPOSED 2No. EMA SUPPORT POLES TO BE FIXED TO WALL, EXISTING EMA SUPPORT POLES TO BE REMOVED. PROPOSED 3No. STAND-OFF BRACKETS c/w 2No. CHS60.3mm, 2.5m LONG ANTENNA SUPPORT POLE & 1No. CHS60.3mm, 4.5m LONG ANTENNA SUPPORT POLE TO BE INSTALLED. PROPOSED 1No. YOKE BRACKET c/w 2No. CHS60.3mm, 2.5m LONG ANTENNA SUPPORT POLES TO BE INSTALLED ON EXISTING EMA SUPPORT POLE

RESERVED H3G & EE 1No. SHF 0.3m HP DISH AT 13.0m BEARING 240° E.T.N I.D. No. 106160 (UNDER ANOTHER PROJECT)

RESERVED H3G & EE 1No. SHF 0.6m HP DISH AT 13.0m BEARING 0° E.T.N I.D. No. 72030 (UNDER ANOTHER PROJECT)

H3G & EE 1No. SHF 0.3m HP DISH AT 13.0m BEARING 101° E.T.N I.D. No. 260896

PROPOSED EE 3No. RD0759 COMBINERS I.D.No. 513515, 513516 & 513517 TO BE INSTALLED ON PROPOSED GANTRY POLE

EE 1No. FCOA CABINET TO BE REFRESHED FOR PROPOSED UPGRADE

PROPOSED EE 3No. 700/800 AHPMDA RRU's I.D. No's. 468227, 468228 & 468229 TO BE INSTALLED ON PROPOSED GANTRY POLE

EE 3No. BOB I.D.No. 471012, 471013 & 471014 TO BE INSTALLED ON PROPOSED GANTRY POLE

H3G & EE GRP 2000x900x400 ACCESS PLATFORM BY EXEL COMPOSITES C/W SAFETY HANDRAIL & ACCESS STEPS

CABIN 1 UNKNOWN

H3G & EE 6No. LDF6-50 FEEDERS (1800) INSTALLED ON EXISTING WALL MOUNTED CABLE TRAY

EE 1No. FCOA CABINET TO BE REFRESHED FOR PROPOSED UPGRADE

PROPOSED EE 3No. 700/800 AHPMDA RRU's I.D. No's. 471006, 471007 & 471008 TO BE INSTALLED ON PROPOSED GANTRY POLE

EE 1No. BOB I.D.No. 471012, 471013 & 471014 TO BE INSTALLED ON PROPOSED GANTRY POLE

 
PROPOSED EE 6No. E1400942 800MHz MHA's TO BE INSTALLED, H3G & EE 3No. E15R02P11 800MHz MHA's & 3No. TMA2053F01V2-1 1800/2100MHz MHA's TO BE RE-USED. EE 3No. DUAL GSM FULL BAND 1800MHz MHA's TO BE REMOVED.

H3G & EE 6No. LCF114-50 FEEDERS, 6No. LDF5-50 FEEDERS & 6No. LCF78-50 FEEDERS TO BE REUSED (SUBJECT TO TESTING). PROPOSED EE 6No. AVA5-50 FEEDERS, 3No. MULTIMODE TRUNK, 3No. SINGLE MODE TRUNK & 3No. POWER ONLY TRUNK TO BE INSTALLED. EXISTING CABLE MANAGEMENT TO BE UTILISED

G.L. 0.0m

PHONE BOX

METER CABINET 3 UNKNOWN



FEINT DETAILS INDICATE LOCATIONS RESERVED FOR OTHER PROPOSALS WHICH MAY BE THE SUBJECT OF SEPARATE APPLICATIONS

Cellnex  
All rights reserved. No part of this publication may be reproduced, stored in a retrieval system or transmitted in any form or by any means (electronic, mechanical, photocopying, recording or otherwise), without the prior written consent of the Company.

#### NOTES

|                      |          |
|----------------------|----------|
| NOMINATION FORM DATE | 22/10/20 |
| NOMINATION REVISION  | v5.0     |
| T-MOBILE CELL ID     | 26762    |

PROJECT No. 226130

CELL No. STM015

BT SKYLINE No. ST0032

| PROJ No | 226130         |          |     |     |
|---------|----------------|----------|-----|-----|
| 11      | PLANNING ISSUE | 01/02/21 | HFC | LBG |
| PROJ No | 171024         |          |     |     |
| 10      | AS BUILT       | 06/11/17 | DAL | AN  |
| PROJ No | 183975         |          |     |     |
| 9       | AS BUILT       | 22/09/17 | MON | FC  |
| PROJ No | 168110         |          |     |     |
| 8       | AS BUILT AMEND | 00/05/18 | HFC | FC  |
| PROJ No | 168110         |          |     |     |
| 7       | AS BUILT       | 01/05/17 | HFC | KL  |
| ISS     | REVISION       | DATE     | DRN | APP |

cellnex  
driving telecom connectivity

Crawley Court, Winchester, Hampshire, SO21 2QA  
Tel: 01962 823434, Fax: 01962 822378

SITE No 168001

LEEK ATE  
ST EDWARDS STREET  
LEEK  
STAFFORDSHIRE  
ST13 5DQ

NGR SJ 98300 56490

OS GRID 398300 356490

TITLE  
ELEVATION  
PROPOSED  
H3G & EE LTD

SCALE 1:100

DRAWN IM 19/08/11

APPROVED LBG 01/02/21

DRG No. Sheet 1 of 1 Rev

168001-02-150-MD011 11