


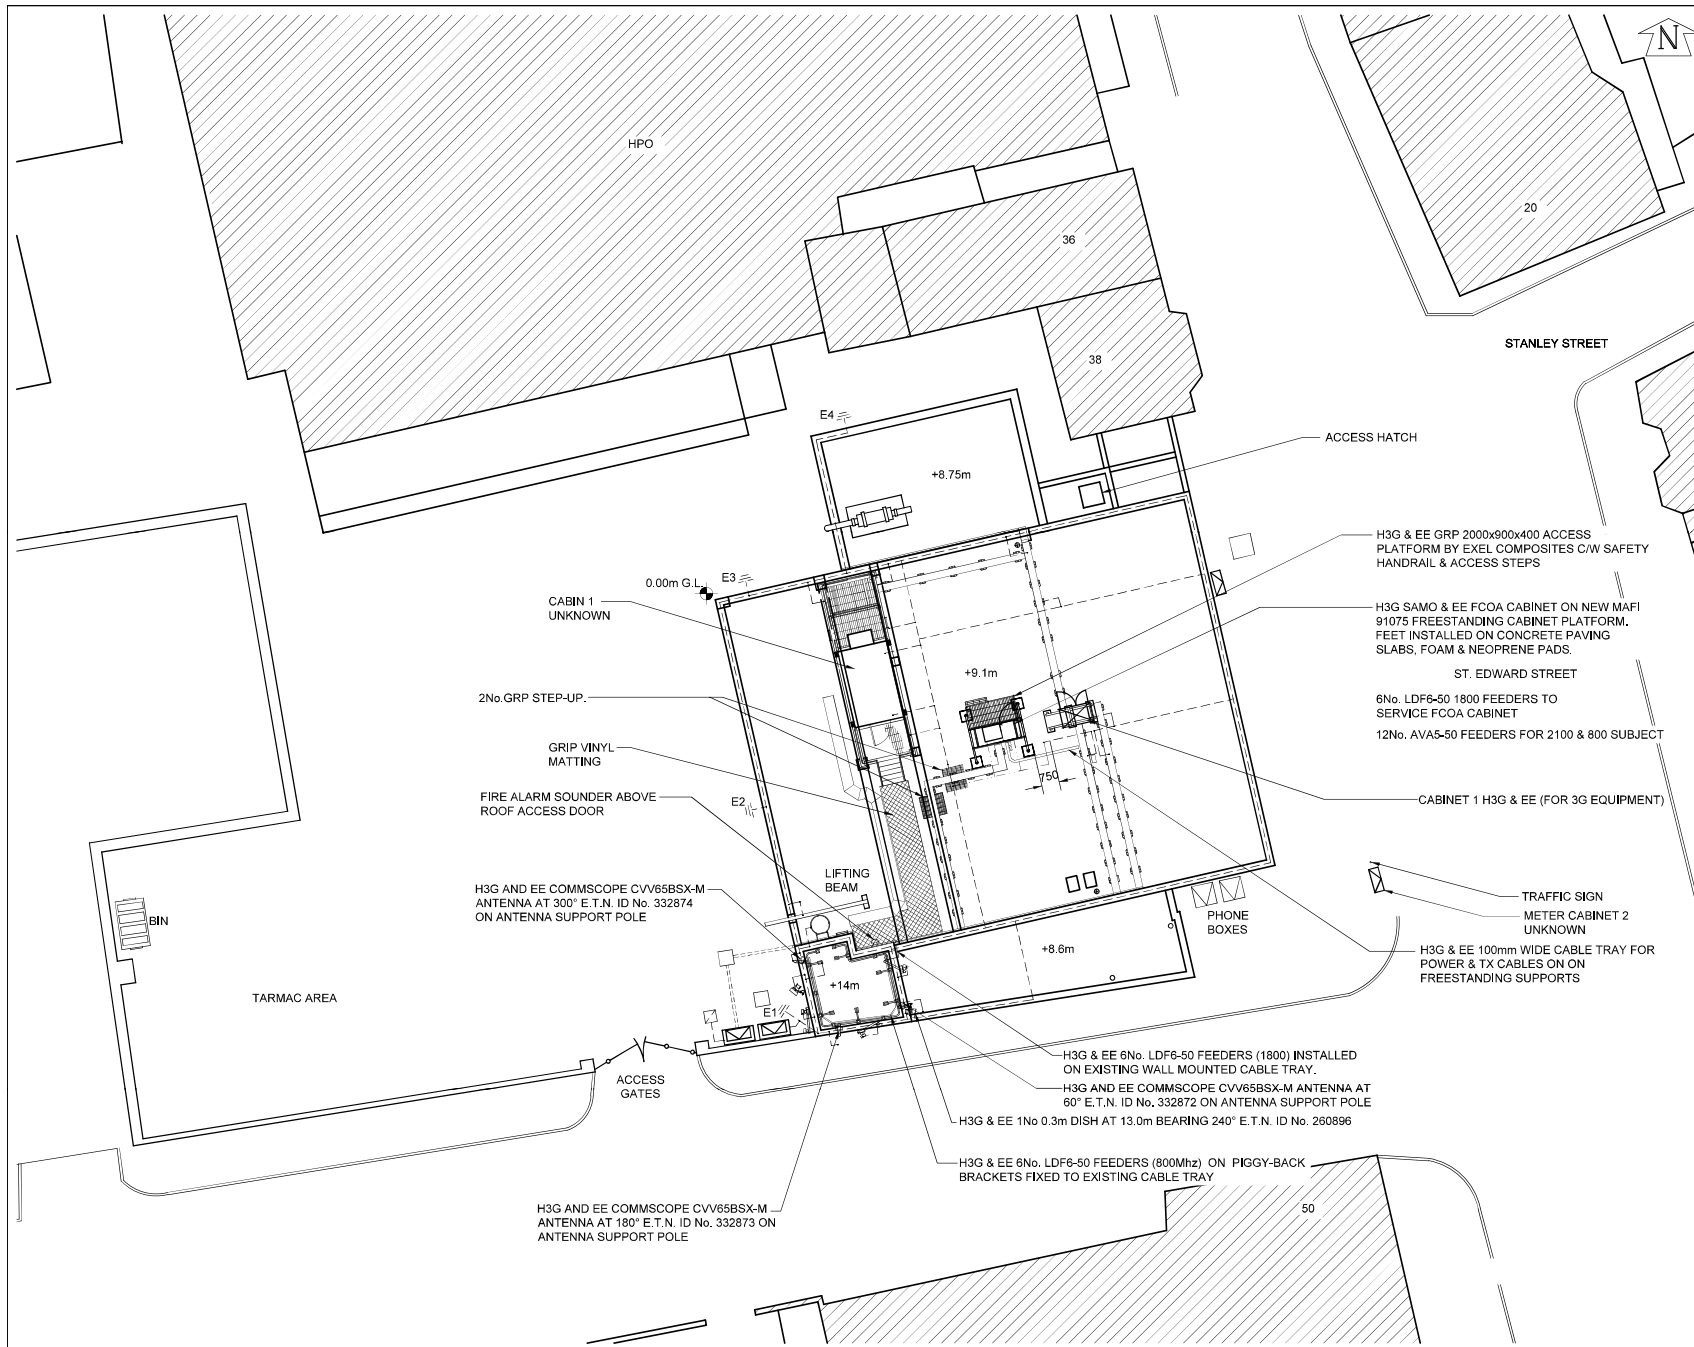

©2020 Cellnex  
All rights reserved. No part of this publication may be reproduced, stored in a retrieval system or transmitted in any form or by any means (Electronic, Mechanical, Photocopying, Recording or otherwise), without the prior written consent of the Company.

**NOTES**

**UNDERGROUND SERVICES**  
UNDERGROUND SERVICES ARE INDICATIVE ONLY. POSITIONS SHOULD BE CONFIRMED ON SITE PRIOR TO ANY DEVELOPMENT

DRAINAGE  
DUCTS  
FEEDERS  
FENCE PLAN  
GAS  
LIGHTNING PROTECTION - EARTHING

POWER  
SERVICES UNKNOWN  
TELECOMS  
WATER

**ACCESS ARRANGEMENTS**

KEYS:-  
ARQVA GATE KEY  
B KEY  
C KEY  
LEGGE KEY

SURVEY REQUIRED TO CONFIRM ACCESS KEYS FOR REMAINING ROOMS AND SITE ENTRANCE

BT SKYLINE No. **ST0032**

|     |                |          |         |
|-----|----------------|----------|---------|
| 11  | PROJ No 226130 | 01/02/21 | HFCLBG  |
| 10  | PROJ No 171024 | 06/11/17 | DAL AN  |
| 9   | PROJ No 193975 | 22/09/17 | MON FC  |
| 8   | PROJ No 168110 | 30/05/17 | HFC FC  |
| 7   | PROJ No 168110 | 01/05/17 | HFC KL  |
| ISS | REVISION       | DATE     | DRN APP |

**cellnex**  
driving telecom connectivity

Crawley Court, Winchester, Hampshire, SO21 2QA  
Tel. 01962 823434, Fax. 01962 822378

SITE No **168001**  
LEEK ATE  
ST EDWARDS STREET  
LEEK  
STAFFORDSHIRE  
ST13 5DQ

NGR SJ 98300 56490  
OS GRID 398300 356490

TITLE  
SITE PLAN  
EXISTING

SCALE 1:200

|          |     |          |
|----------|-----|----------|
| DRAWN    | IM  | 19/08/11 |
| APPROVED | LBG | 01/02/21 |

|                     |              |     |
|---------------------|--------------|-----|
| DRG No.             | Sheet 1 of 1 | Rev |
| 168001-00-000-MD011 |              | 11  |

A3