

Notes:

Abbreviations/Symbols (Measured Building Surveys):

C:	Window Cill Height
H:	Window Head Height
BH:	Beam Height
DH:	Door Height
COL:	Column
SV/P:	Soil Vent Pipe
FL:	Floor Level
TH:	Threshold Level
⌀	Floor to Ceiling Height
⌒	Vaulted Ceiling

Line types

— — — —	Hedge Lines
— · — · —	Drainage Runs
- - / - -	Overhead Electricity Cables
- - 1 - -	Overhead Telephone Cables

Symbols




	Tree/Bush		Control Station
	Borehole		Trial Hole

Abbreviations (Topographic Survey):

AH:	Arch Height
AV:	Air Valve
BB:	Belisha Beacon
BOX:	Electricity Box, Cables Box, Etc.
BOL:	Bollard
BT/IC:	British Telecom Inspection Chamber
BS:	Bus Stop
BS/LP:	Bus Stop / Lamp Post
CATV:	CATV Inspection Chamber
CCTV:	Closed Circuit Television
CL:	Cellar Light
C.PIT:	Catch Pit
ER:	Earth Rod
EC:	Electricity Inspection Chamber
EP:	Electricity Pole
FH:	Fire Hydrant
FP:	Frog Pole
GV:	Gas Valve
G:	Gully
IC:	Inspection Chamber
KO:	Kerb Outlet
LP:	Lamp Post
LB:	Litter Box
LC:	Lighting Column
MKR:	Marker
MHL:	Manhole
MP:	Mooring Point
MS:	Mile Stone
NYNEX:	Nymex Inspection Chamber
O/H:	Over Hang
P:	Post
PO/IC:	Post Office Inspection Chamber
R/S:	Road Sign
RE:	Rodding Eye
RTW:	Retaining Wall
S/P:	Sign Post
SNP:	Street Name Plate
ST:	Stop Tap
SV:	Stop Valve
T:	Telecom Inspection Chamber
TCB:	Telephone Call Box
TH:	Threshold Level
TL:	Traffic Light
TP:	Telegraph Pole
TROUGH:	Trough
WO:	Water Outlet
WM:	Water Meter

Fence Descriptions:

B/W:	Barbed Wire
C/B:	Close Boarded
C/BARRIER:	Crash Barrier
C/L:	Chain Link
C/P:	Chestnut Paving
C/I:	Corrugated Iron
I/R:	Iron Rolling
MISC:	Miscellaneous
P/R:	Post & Rail
P/W:	Post & Wire
P/C:	Post & Chain
S/PAL:	Steel Palisade
W/M:	Wire Mesh

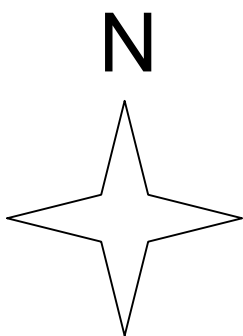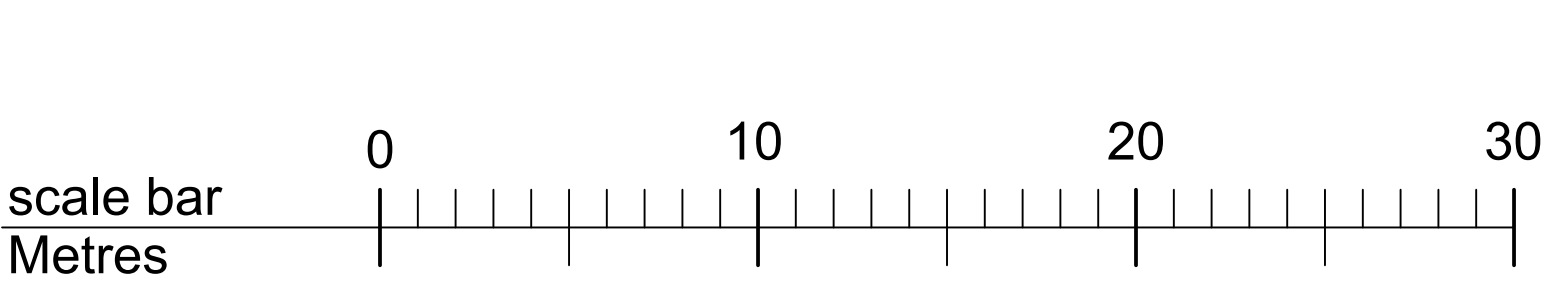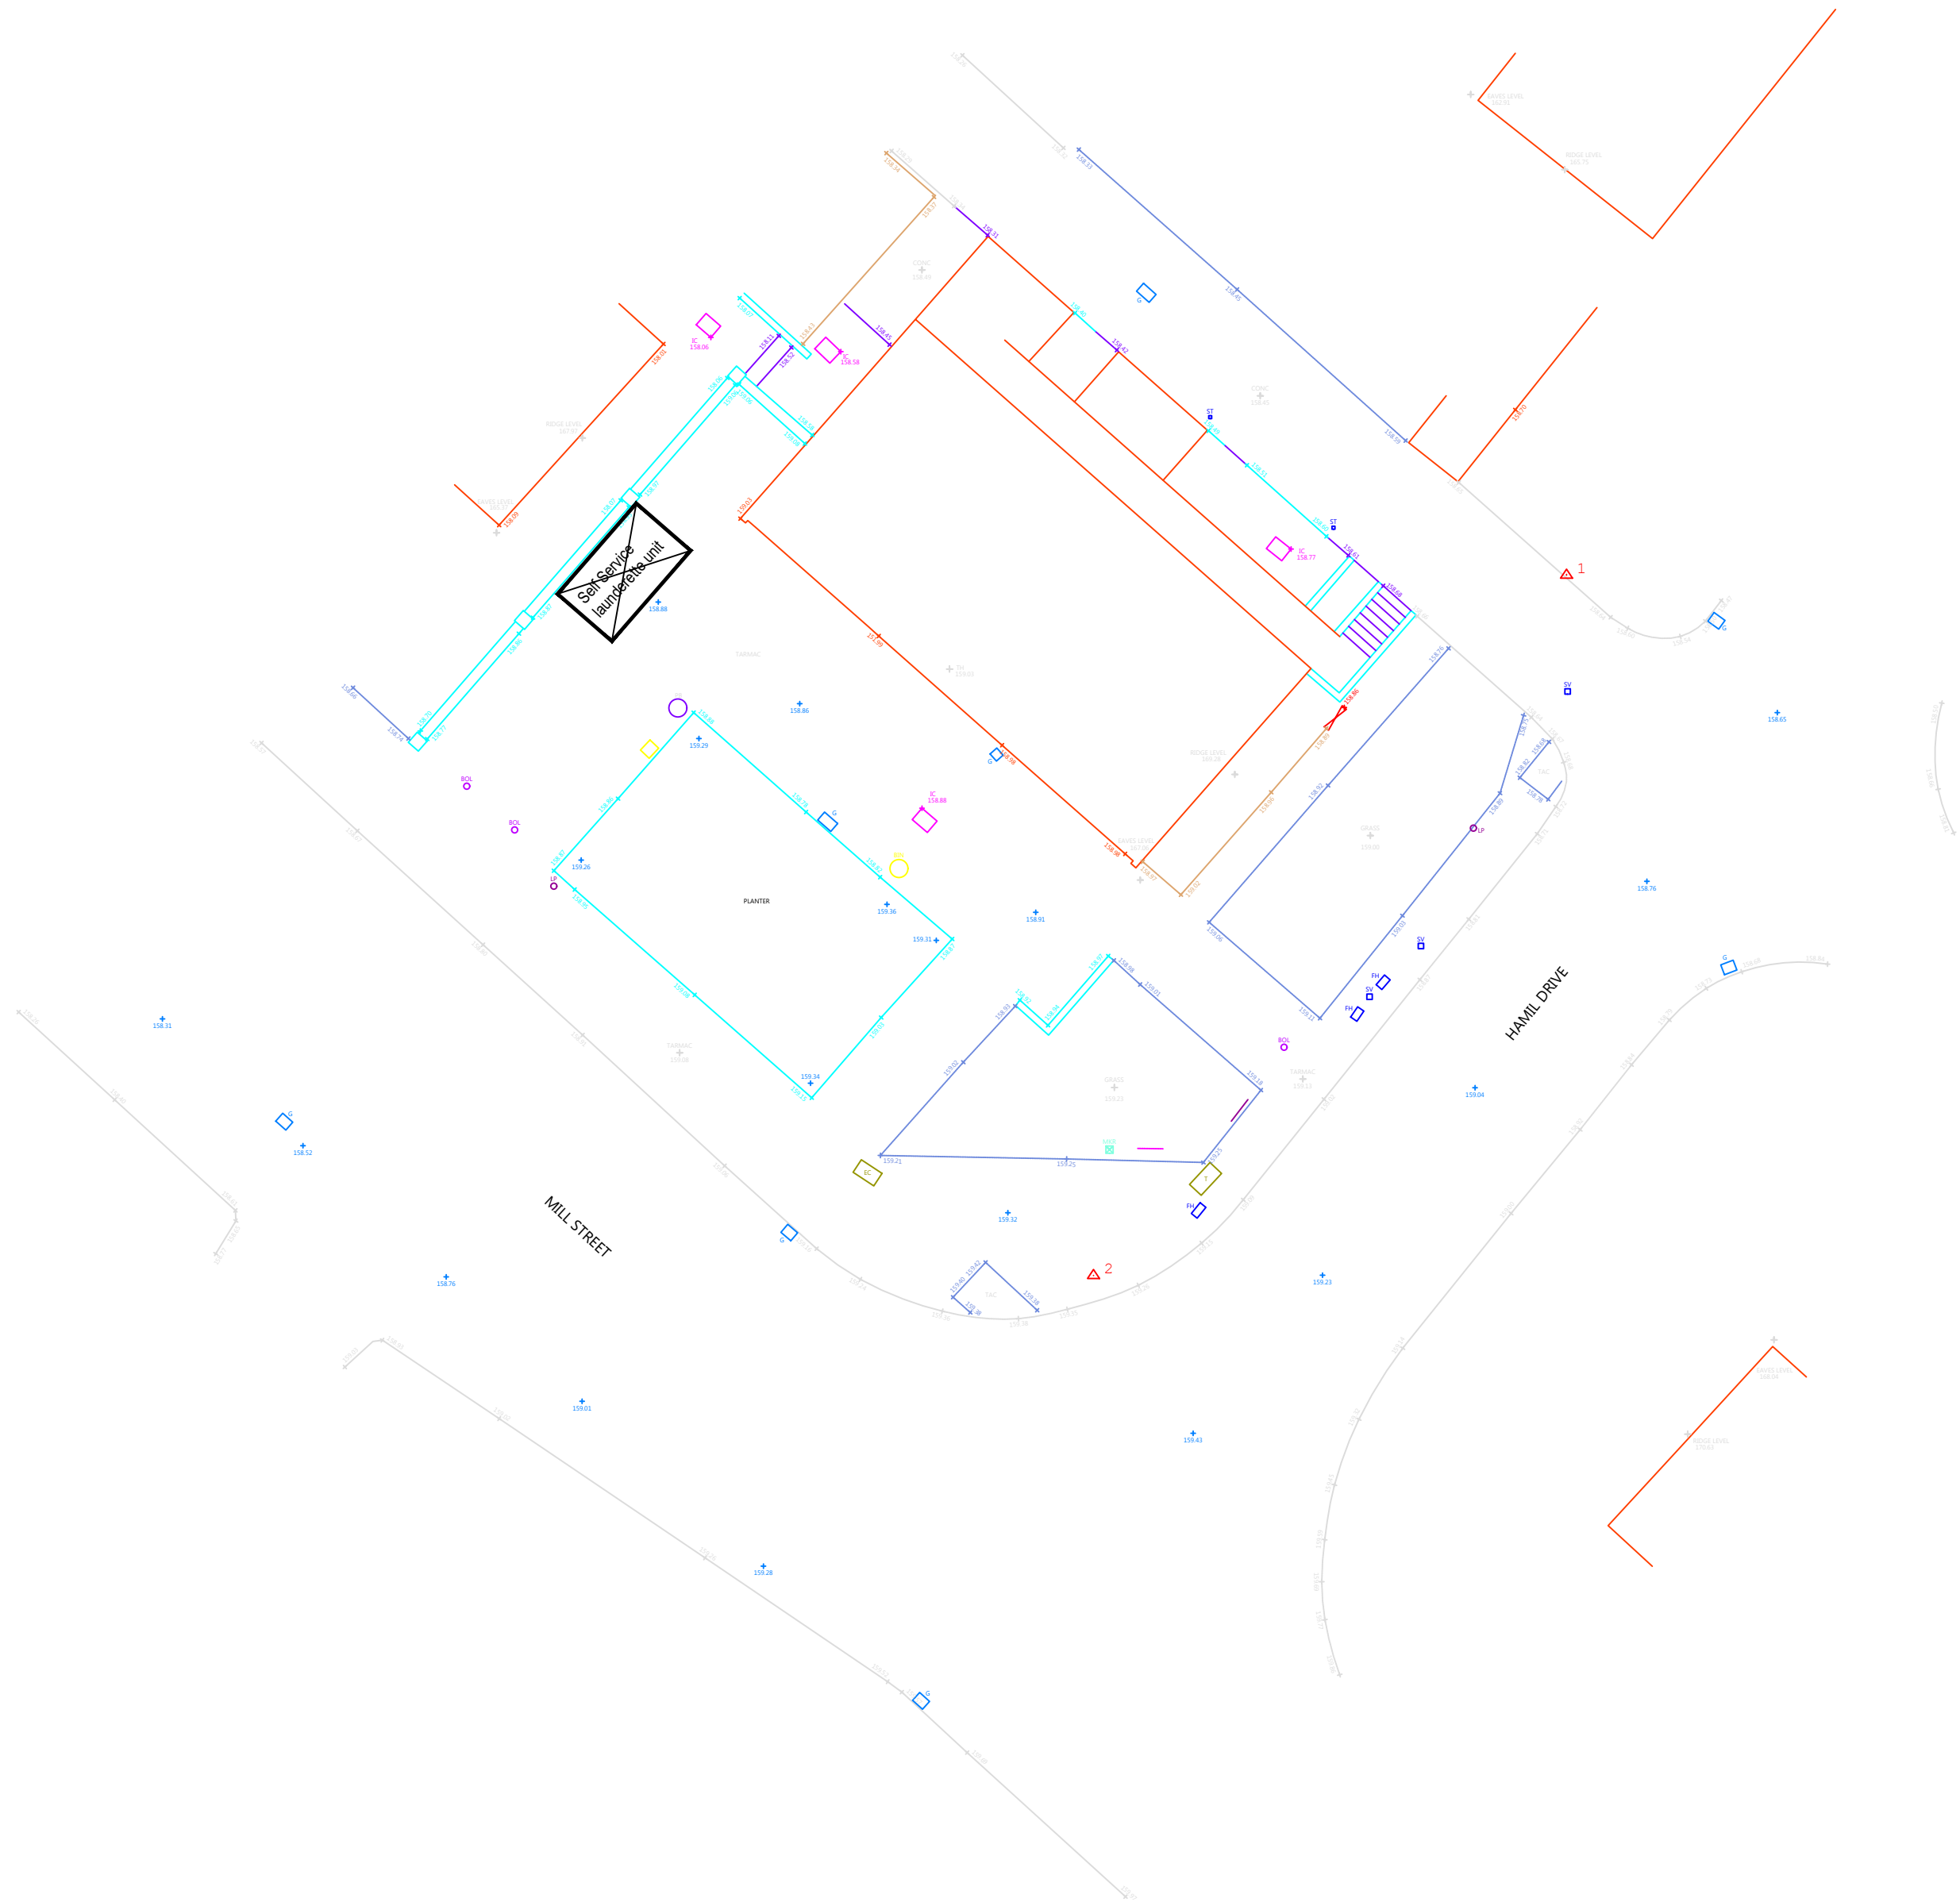

Project:	YHG 156-168 Mill Street Parking Development		
Title:	Existing Site Plan		
Date ::	November 2021	Drawn by ::	RC
Scale ::	1:200 @ A1	Checked by ::	
Issue ::		Office ::	Ecology Park
Revision # ::		Dwg status ::	Planning
Drawing # ::	GM 2378 06		

GROUNDWORK GREATER MANCHESTER

Trafford Ecology Park
Lake Road
Trafford Park
Manchester M17 1TU
Tel: 0161 220 1000

