




THE MATERIAL CONTAINED IN THIS DRAWING HAS BEEN BASED UPON THE ORDNANCE SURVEY MAP BY SEVERN TRENT WATER LTD. BY PERMISSION OF ORDNANCE SURVEY ON BEHALF OF THE CONTROLLER OF HER MAJESTY'S STATIONERY OFFICE.
CROWN COPYRIGHT - SEVERN TRENT WATER LTD. - 100031673
DOCUMENT USERS, OTHER THAN SEVERN TRENT WATER BUSINESS USERS, ARE ADVISED THAT THIS DOCUMENT IS PROVIDED FOR REFERENCE PURPOSE ONLY AND NO FURTHER COPIES SHOULD BE MADE FROM IT.

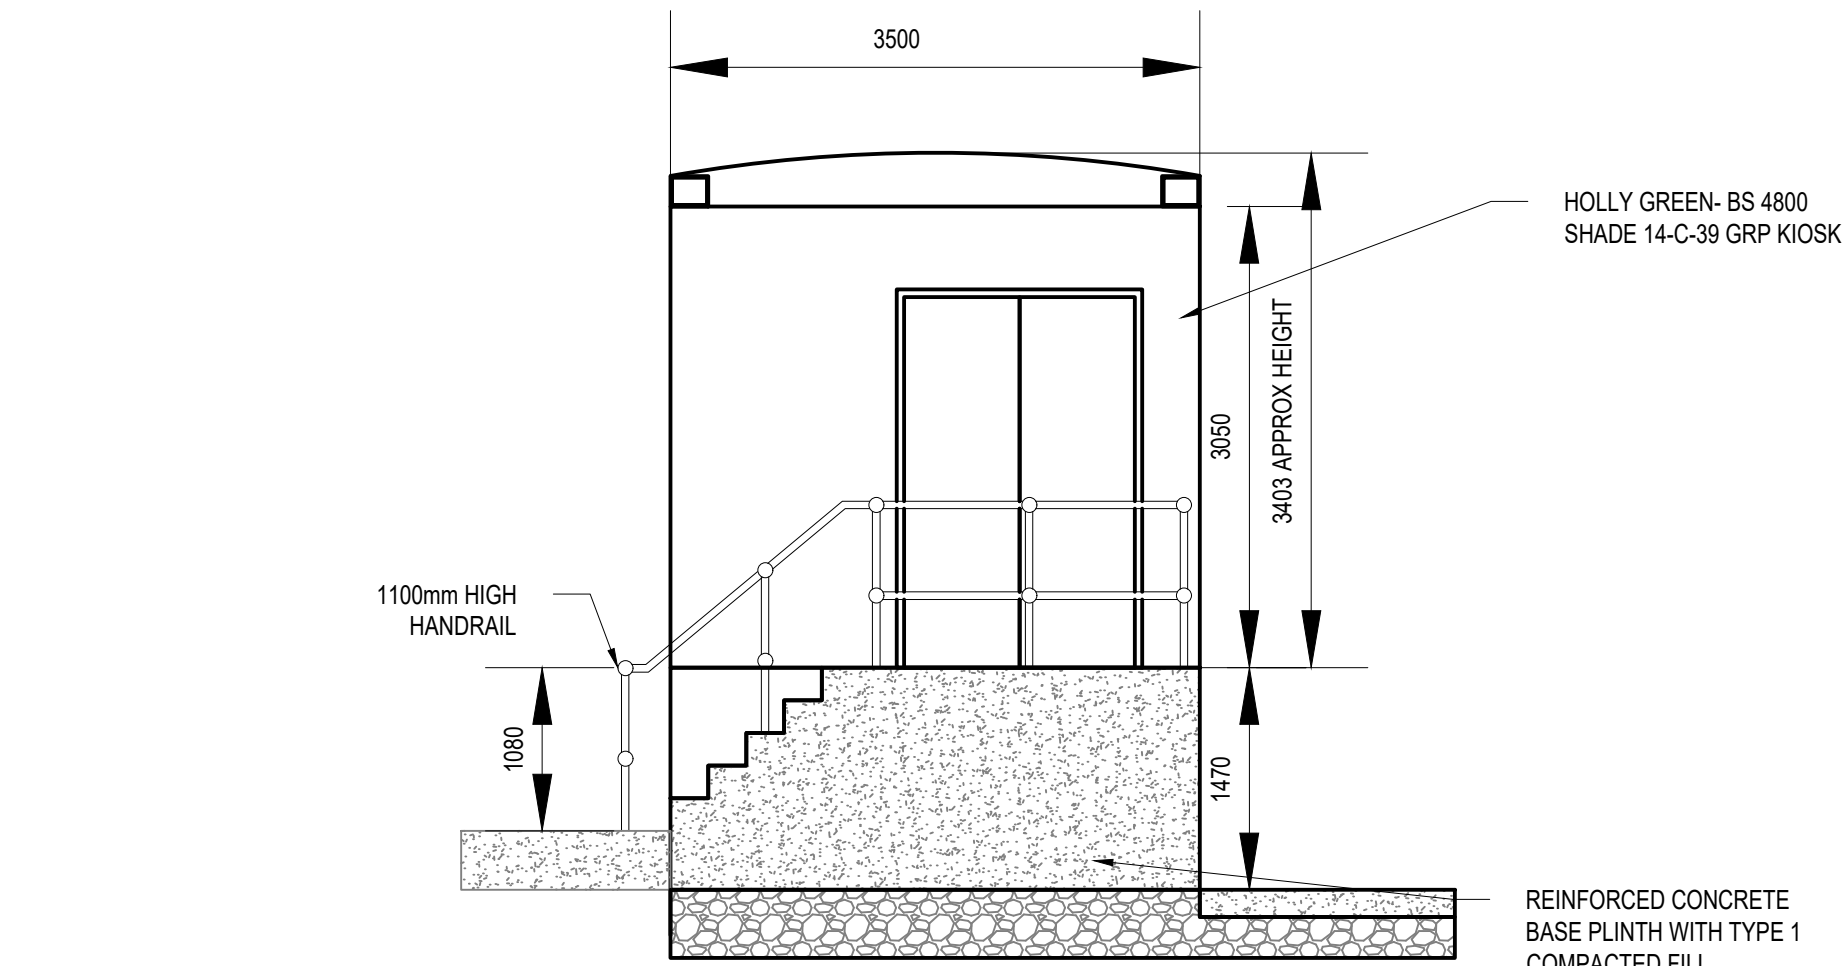


SAS FEED PUMPS KIOSK NORTH ELEVATION

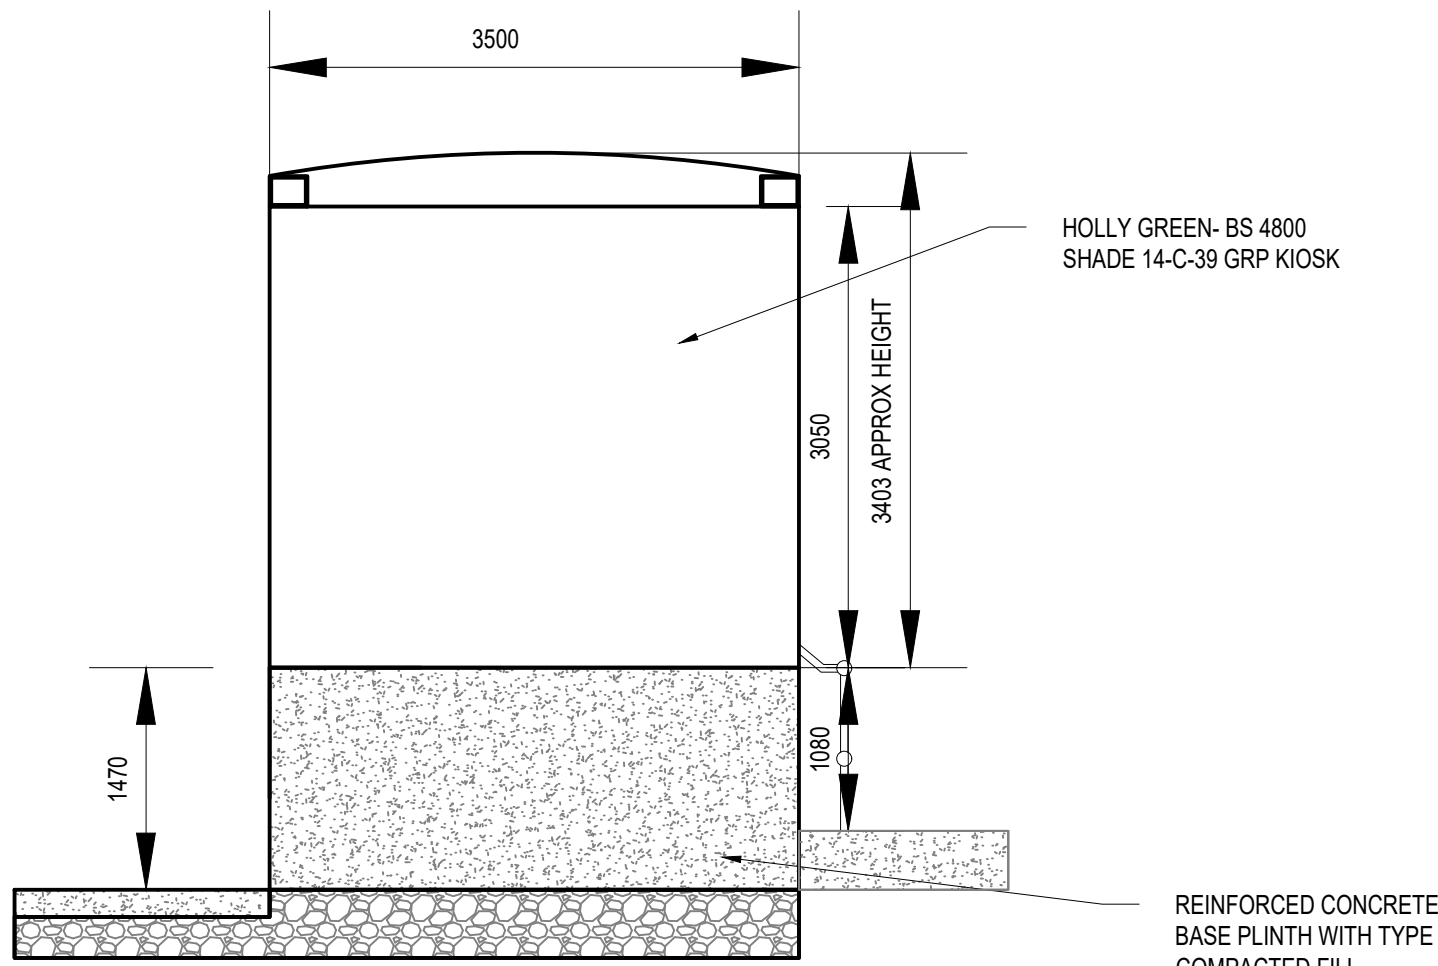

SAS FEED PUMPS KIOSK SOUTH ELEVATION

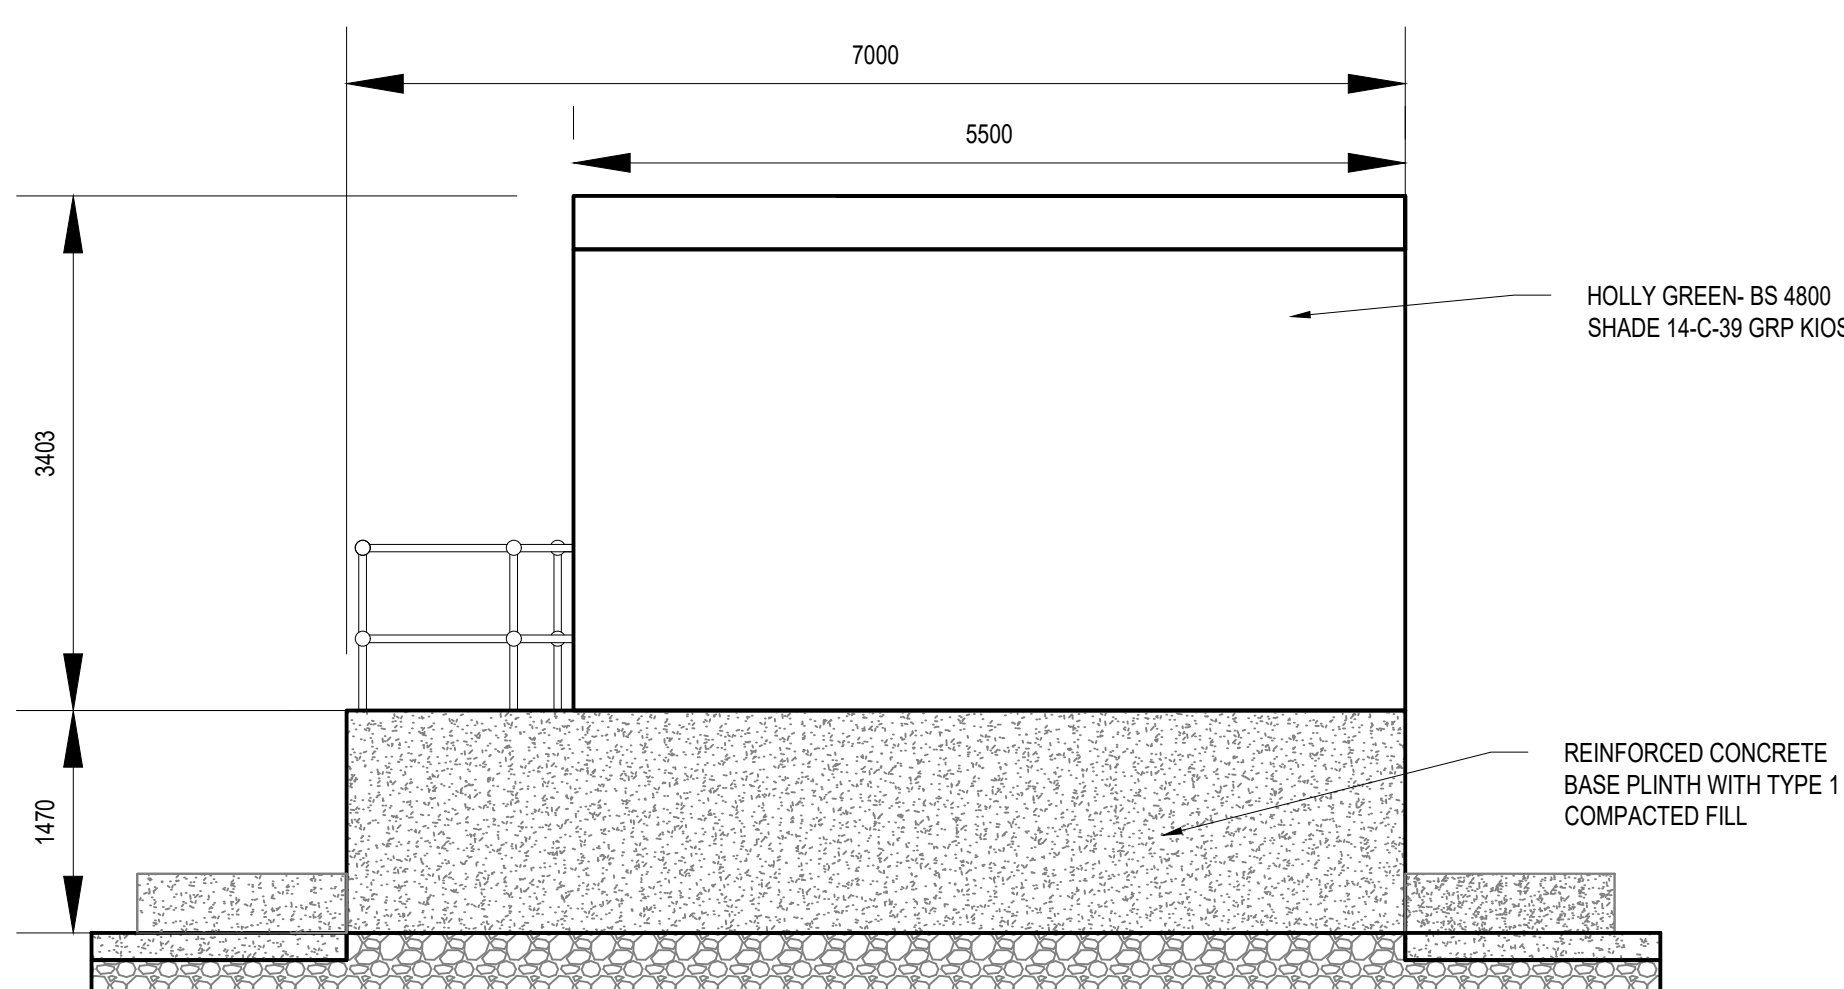

SAS FEED PUMPS KIOSK WEST ELEVATION

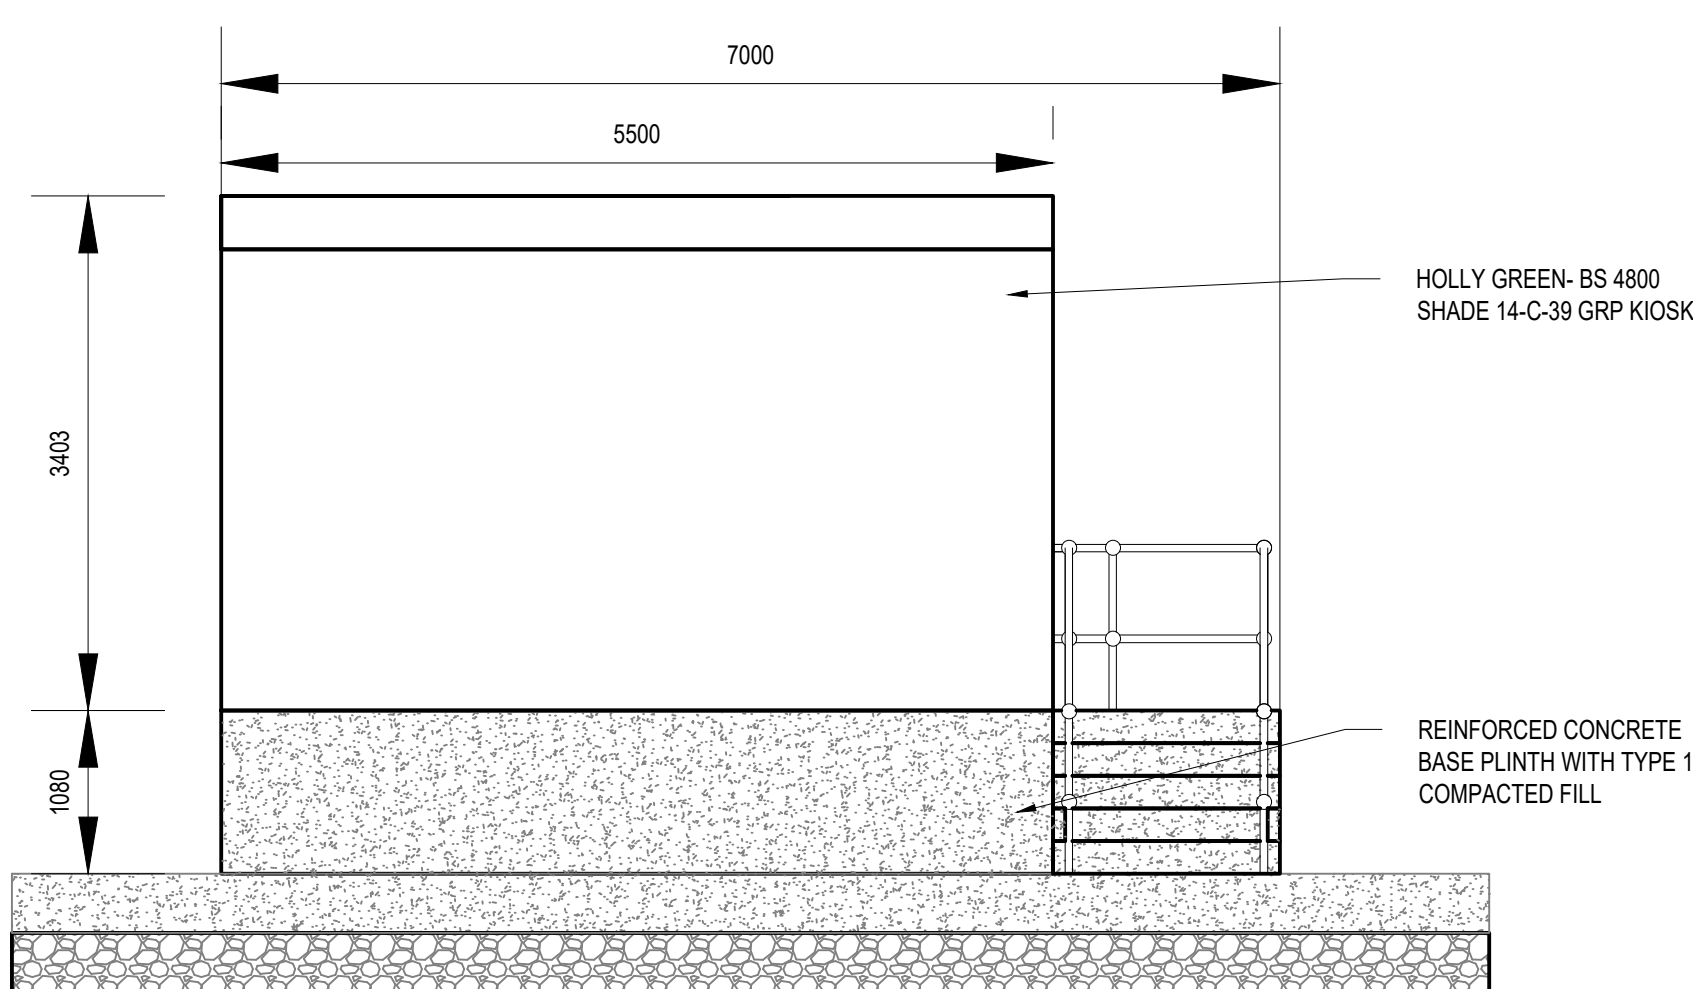

SAS FEED PUMPS KIOSK EAST ELEVATION

DO NOT SCALE
USE WRITTEN DIMENSIONS ONLY


HEALTH & SAFETY

SITE HAZARDS

PLEASE REFER TO DRAWING NO. A7S13578-DCL-XX-ZZ-DR-C-0002.

- NOTES;
1. ALL DIMENSIONS IN MILLIMETRES AND ALL LEVELS IN METRES AOD UNLESS SHOWN OTHERWISE.
 2. THIS DRAWING MUST BE READ IN CONJUNCTION WITH ALL RELEVANT ENGINEERS DRAWINGS AND DOCUMENTATION.
 3. ALL PIPES WITH COVER GREATER THAN 1.2m BENEATH ROADS AND 0.9M BENEATH OTHER AREAS TO BE REINSTATED AS PER SEVERN TRENT WATER STANDARD DETAIL STD6071.
 4. ALL PIPES WITH COVER LESS THAN 1.2m BENEATH ROADS AND 0.9m BENEATH OTHER AREAS TO HAVE PIPE PROTECTION DETAIL AS PER SEVERN TRENT WATER STANDARD DETAIL STD6072.
 5. ALL MANHOLES TO BE MIN. 1200mm DIAMETER TO SEVERN TRENT WATER DETAIL STD6054 TYPE E.
 6. THE CONTRACTOR IS TO VERIFY ALL LEVELS AND SIZES OF EXISTING PIPEWORK PRIOR TO COMMENCEMENT OF WORK.
 7. CONTRACTOR TO CONFIRM LOCATION OF ALL SERVICES PRIOR TO COMMENCEMENT OF PROJECT BY LIAISON WITH STATUTORY AUTHORITIES AND REFERENCE TO SERVICE DRAWINGS WHERE APPROPRIATE. ALL OVERHEAD CABLES TO BE IDENTIFIED.
 8. SETTING OUT IS THE RESPONSIBILITY OF THE CONTRACTOR. ANY DISCREPANCY IN THE POSITION OF SERVICES AND/OR OBSTRUCTIONS ON THE LINE AND OR LEVEL OF THE PROPOSED WORKS SHOULD BE REPORTED TO THE ENGINEER.
 9. ALL SURFACING TO BE REINSTATED TO MATCH EXISTING FINISH AND LEVELS.
 10. ANY DAMAGE TO EXISTING SERVICES MUST BE REPORTED TO APPROPRIATE UTILITY PROVIDER AND THE PROJECT MANAGER.
 11. NO EXCAVATIONS SHOULD BE LEFT OPEN DURING TIMES WHEN THE SITE IS LEFT UNATTENDED. SUITABLE FENCING SHOULD BE ERECTED AROUND THE AREA OF WORK.
 12. WHERE PROPOSED PIPEWORK CROSSES EXISTING SERVICES A MINIMUM OF 150mm CLEARANCE MUST BE GIVEN AND PACKED WITH A GRANULAR MATERIAL BETWEEN PROPOSED AND EXISTING PIPES.

LEGEND	
	PROPOSED STRUCTURES
	PROPOSED SLUDGE PUMPING MAINS
	PROPOSED CHEMICAL DOSING
	PROPOSED SITE DRAINAGE
	PROPOSED GRAVITY FOUL SEWER
	EXISTING GRAVITY FOUL SEWER
	EXISTING AERATION PIPEWORK
	PROPOSED SITE LEVELS
	PROPOSED EXTENSION TO ACCESS ROAD

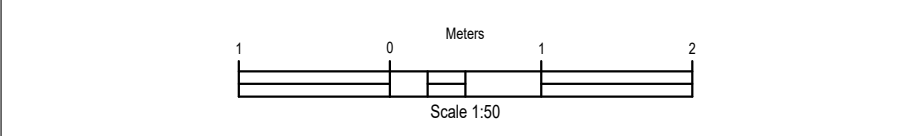

PROJECT TITLE

 
A7S-13578
ALTON STW AMP7

DRAWING TITLE

SAS FEED PUMPS KIOSK ELEVATIONS

DRAWING NO:

A7S13578-DCL-XX-ZZ-DR-T-0005 P01-02

SCALE:	1:50	SHEET SIZE:	A1	
THIS DRAWING IS CONFIDENTIAL AND THE PROPERTY OF SEVERN TRENT AND MUST NOT BE REPRODUCED WITHOUT WRITTEN PERMISSION				