



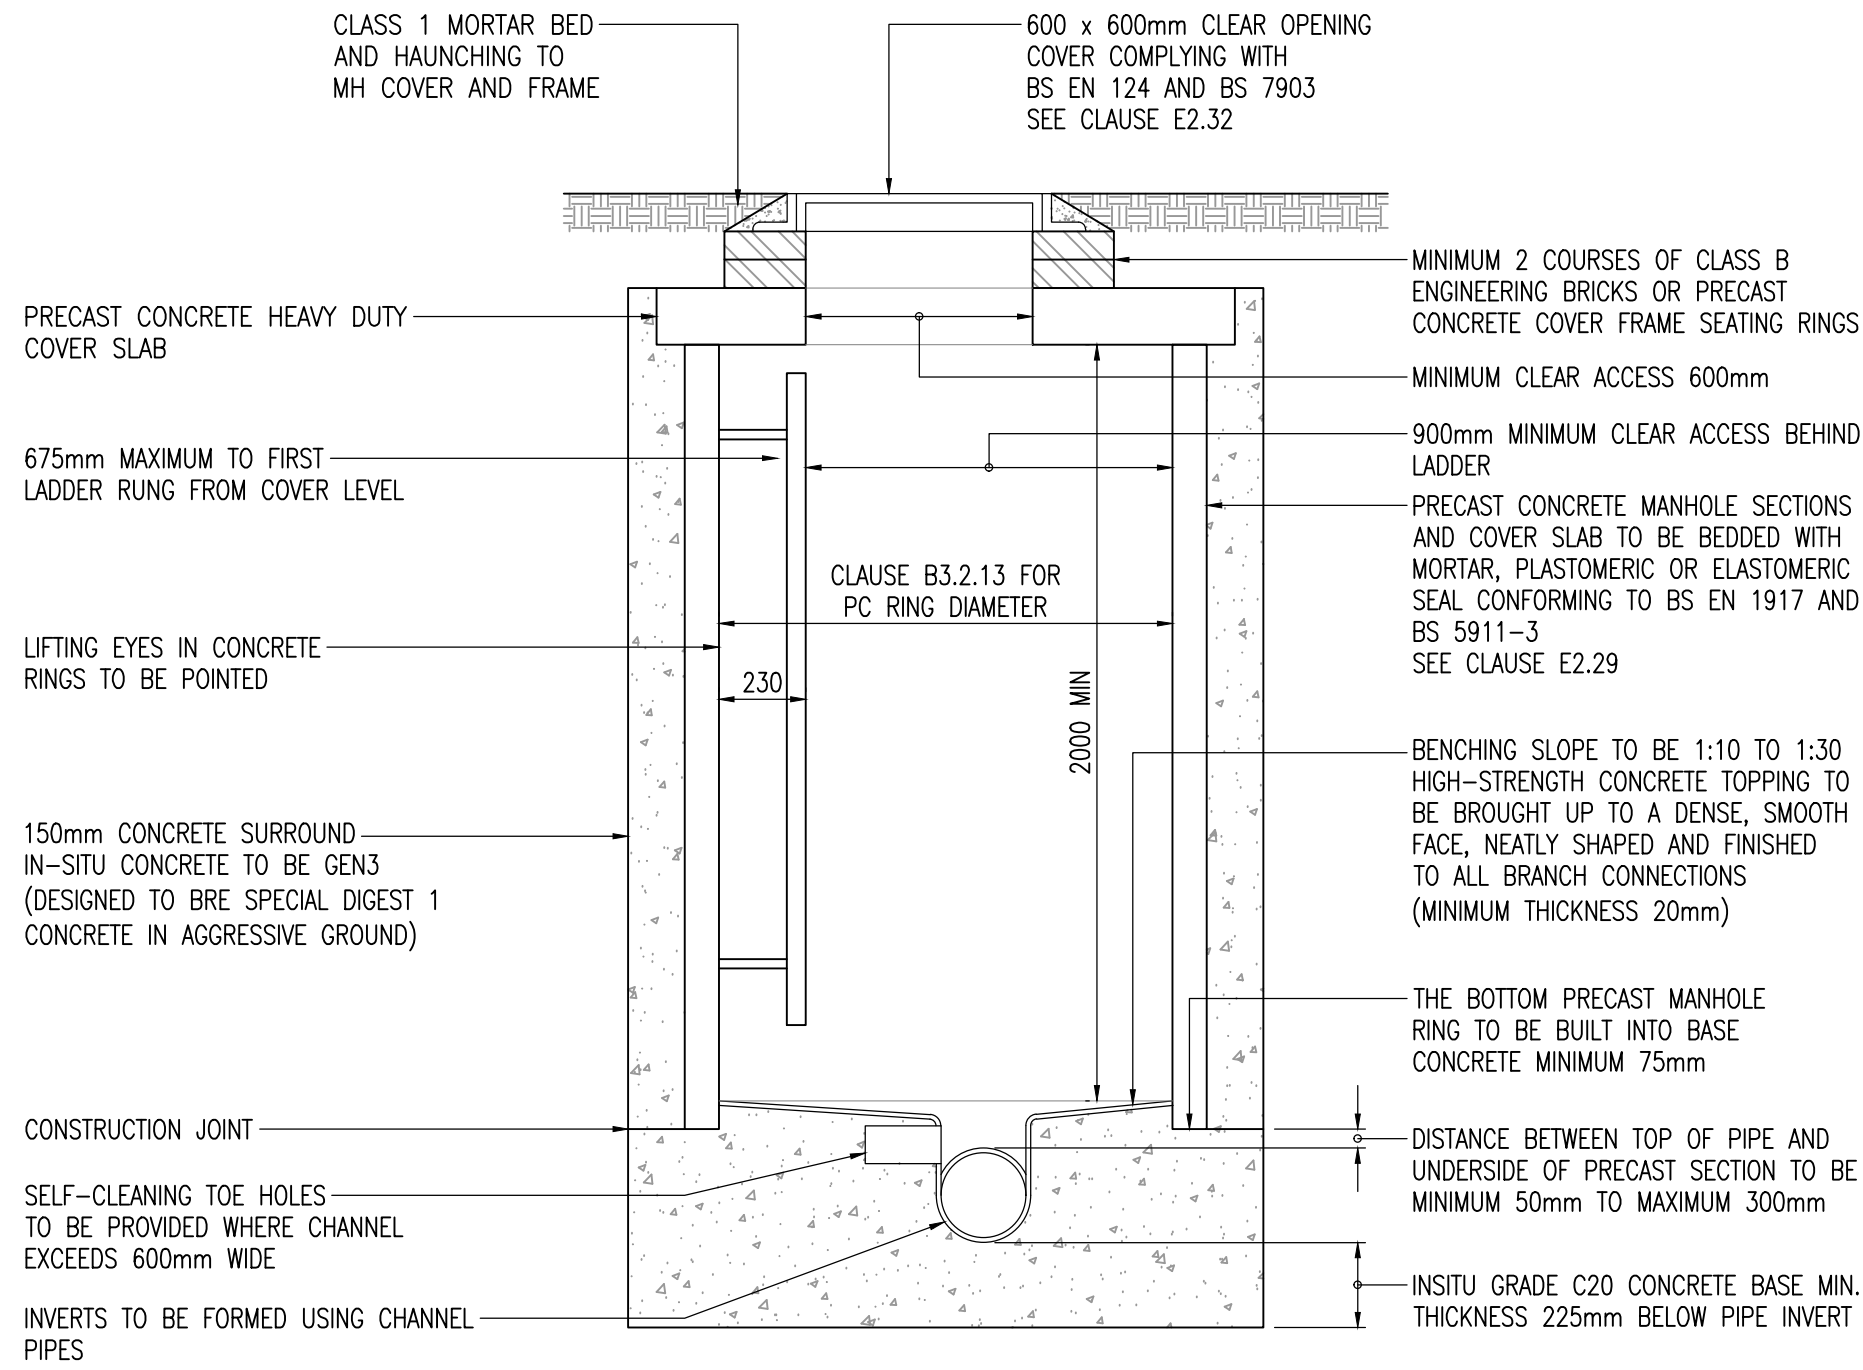


SECTION A-A

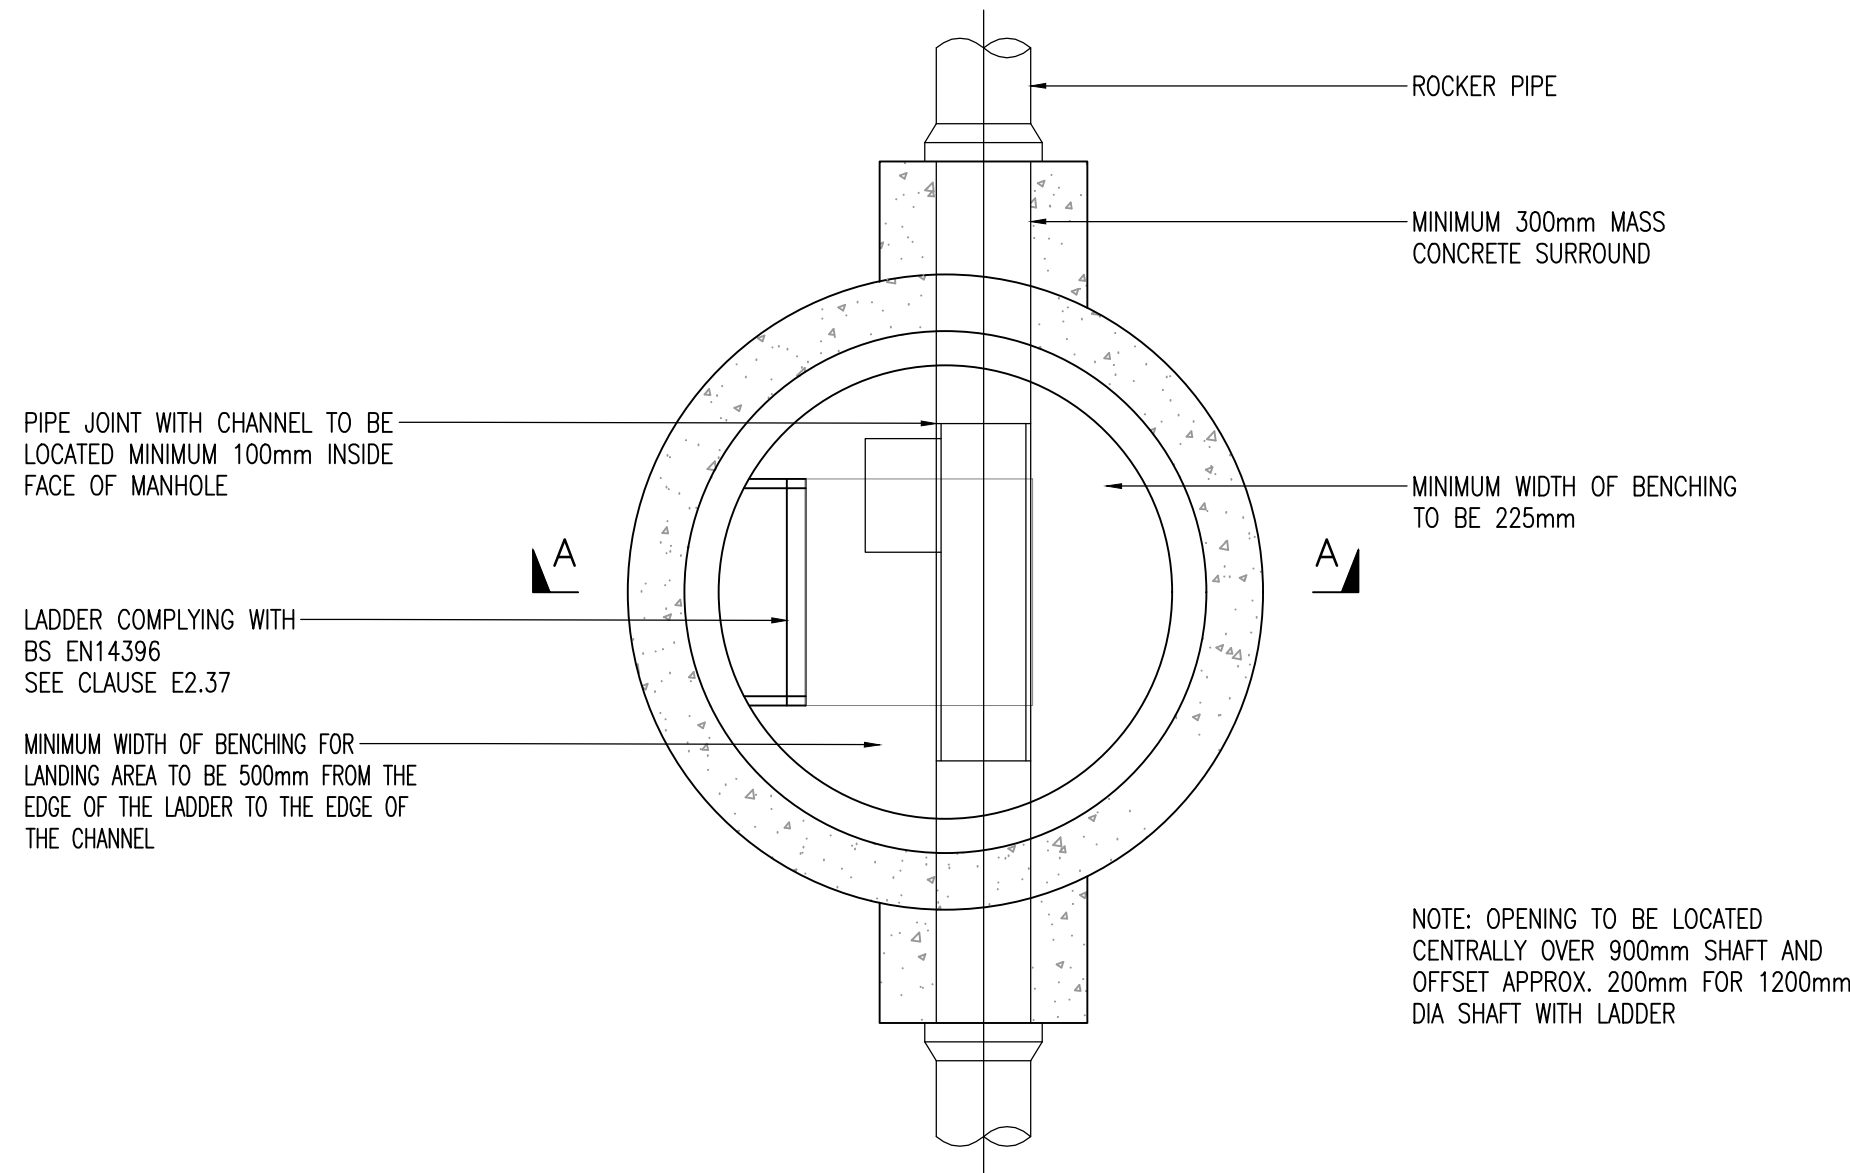

MANHOLE TYPE 1B


DEPTH FROM COVER LEVEL TO SOFFIT OF PIPE 3m TO 6m

(1:20)

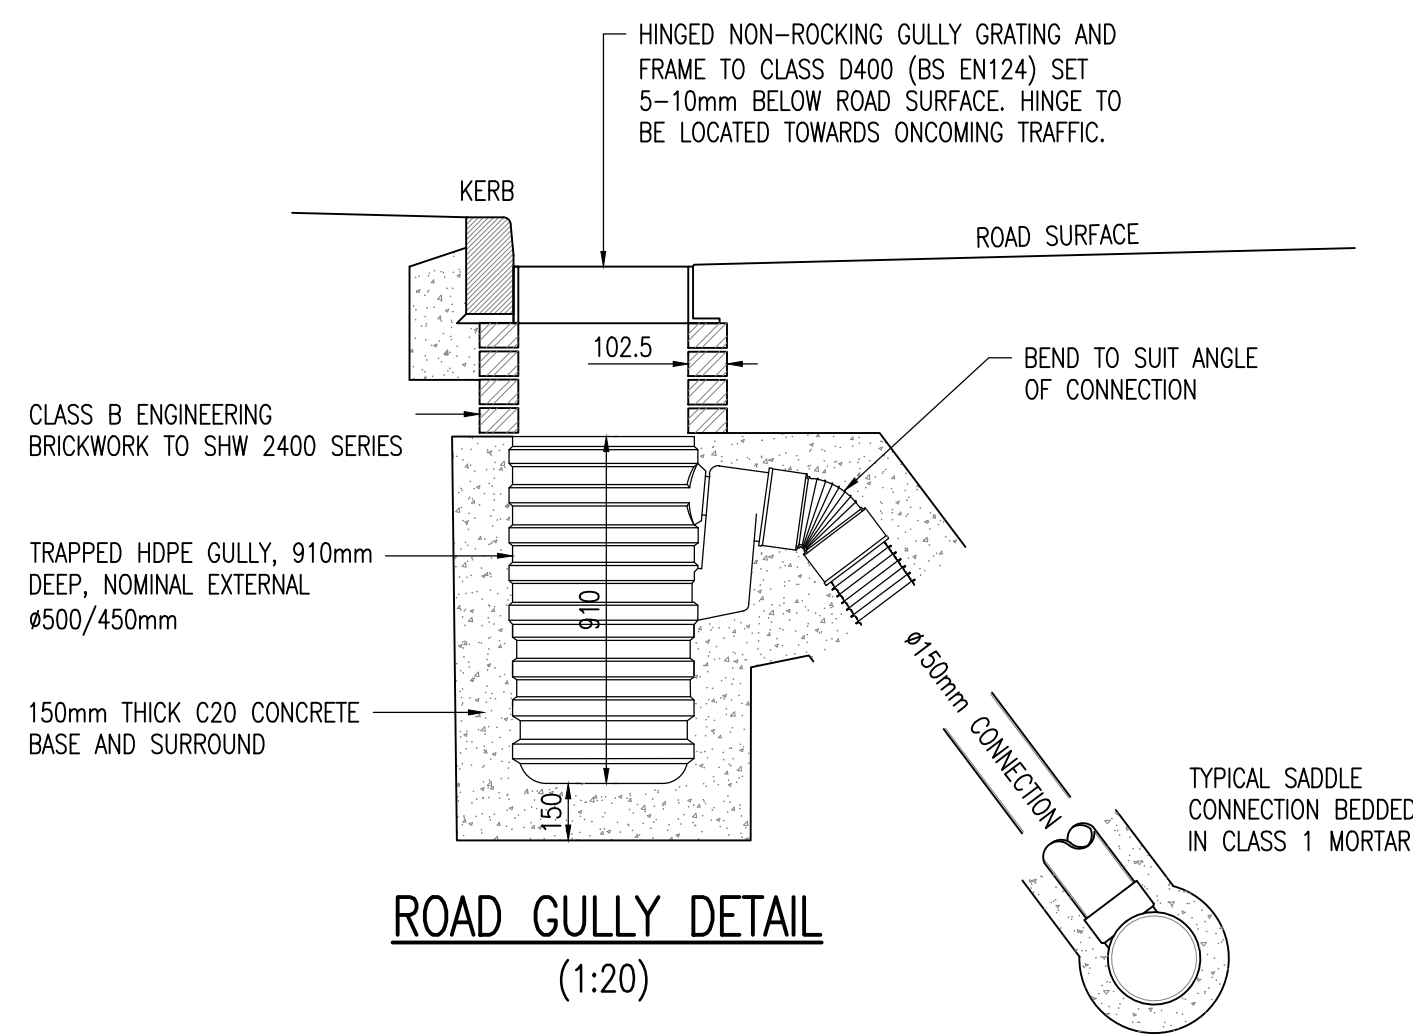


ROAD GULLY DETAIL

(1:20)

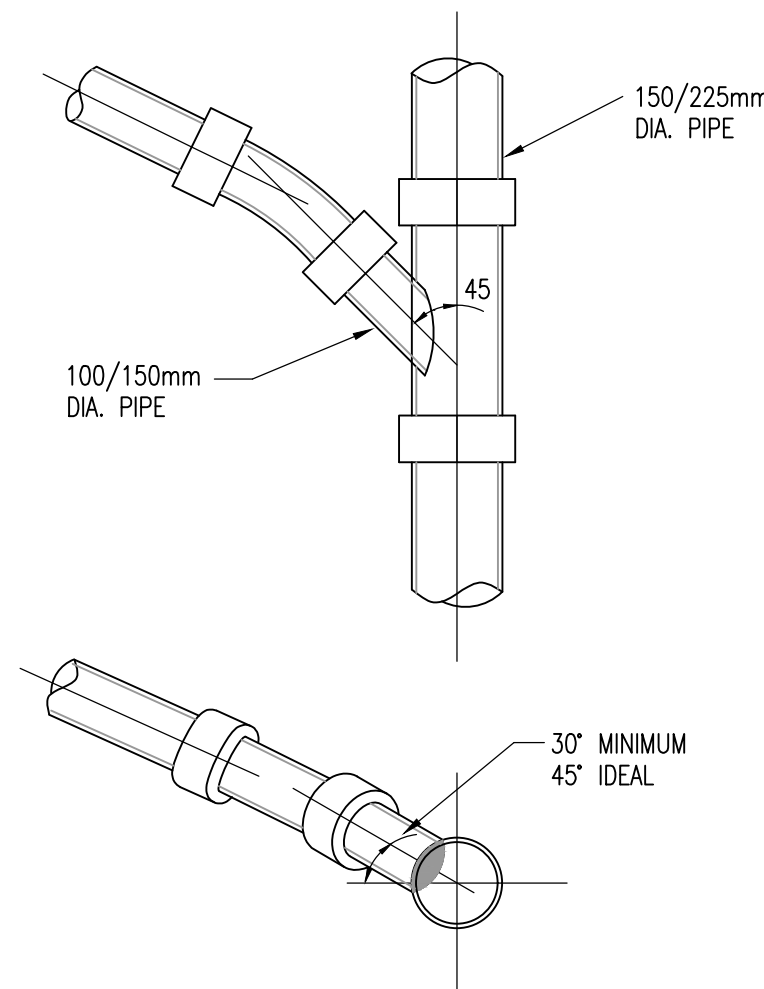


TYPICAL BRANCH CONNECTION


(N.T.S.)

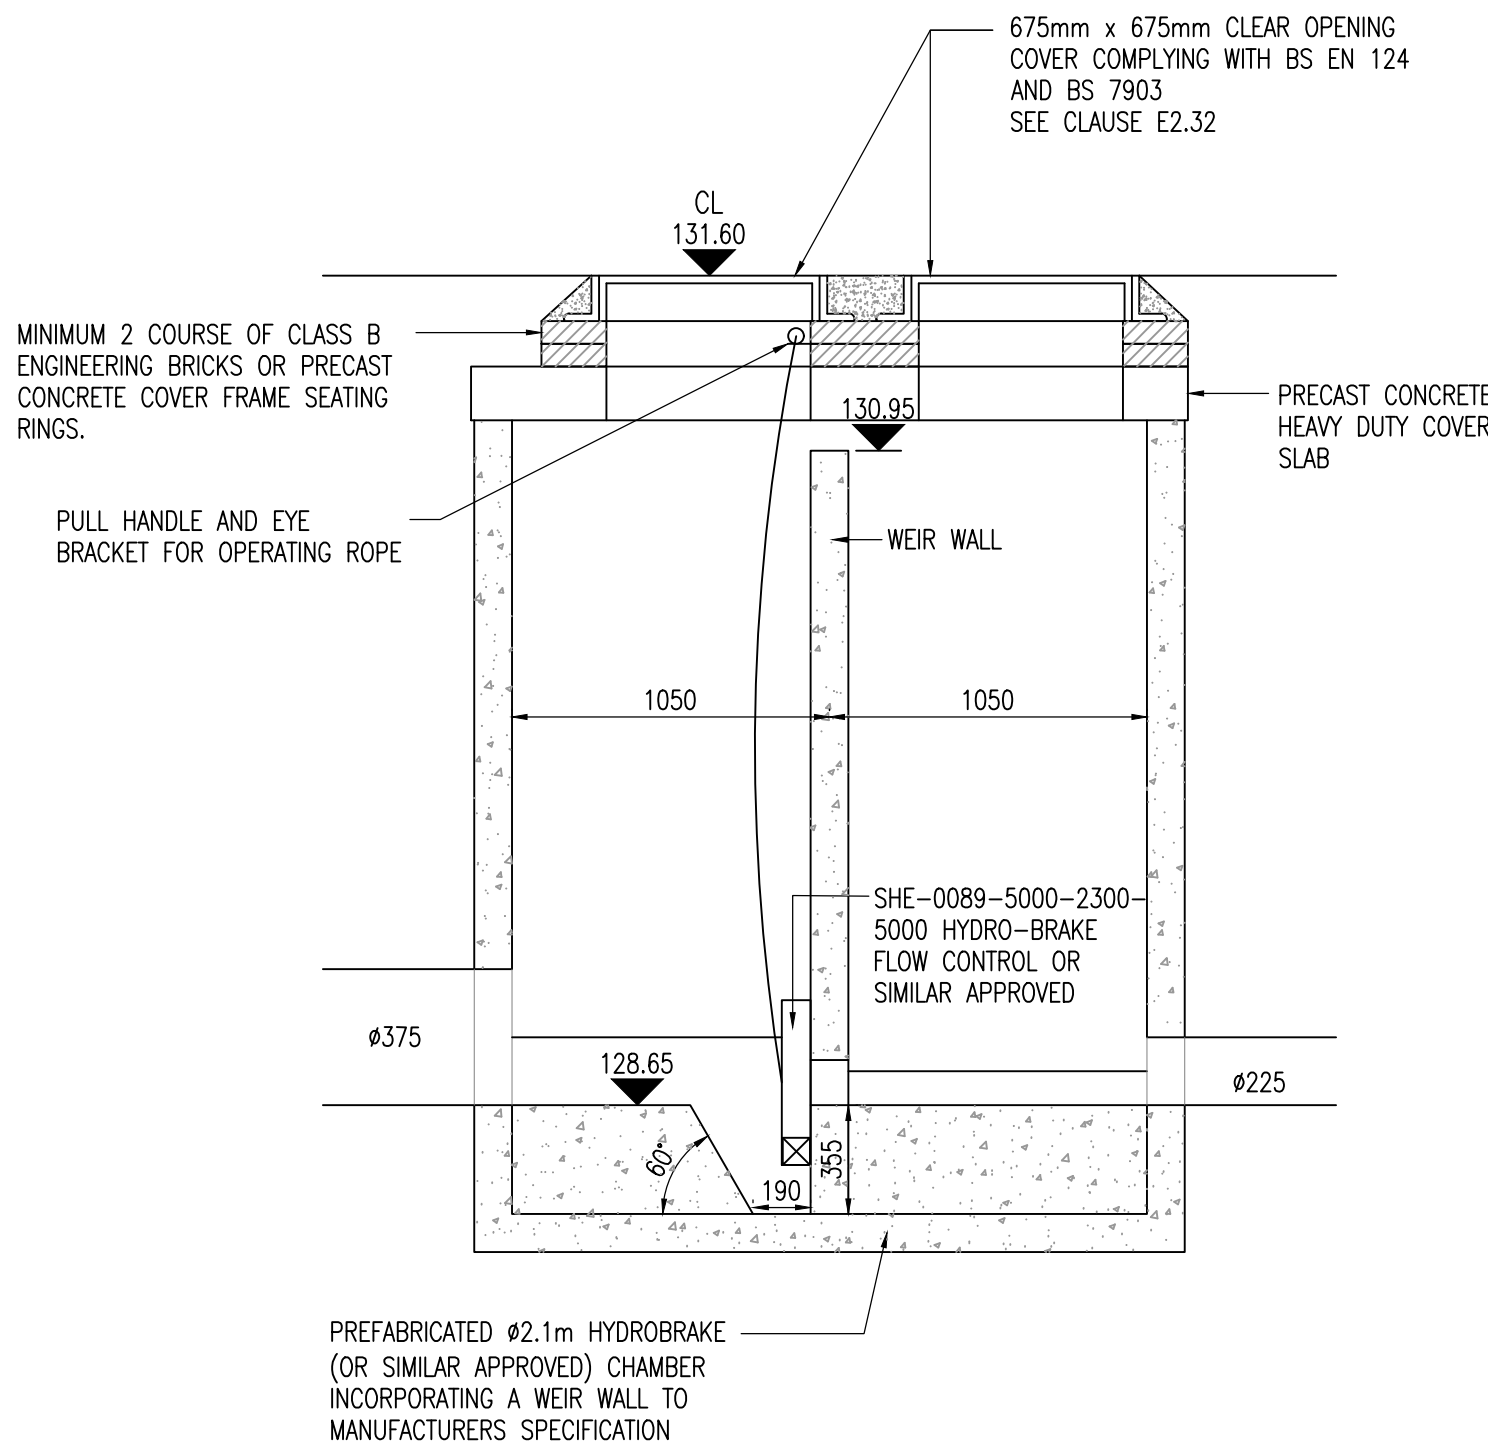

SECTION A-A

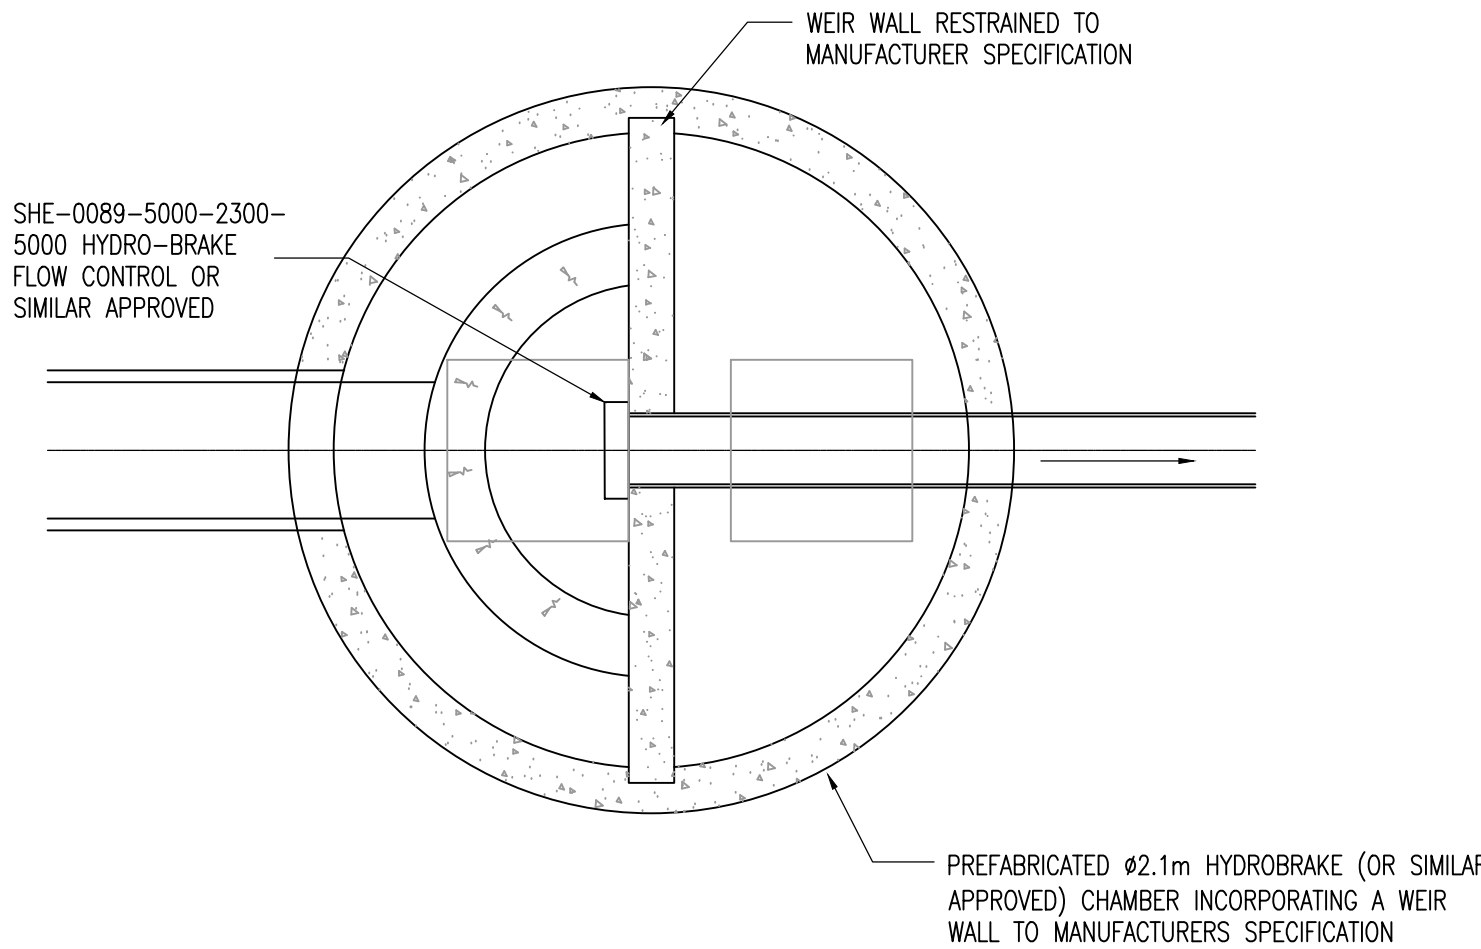


HYDRO-BRAKE MANHOLE S15

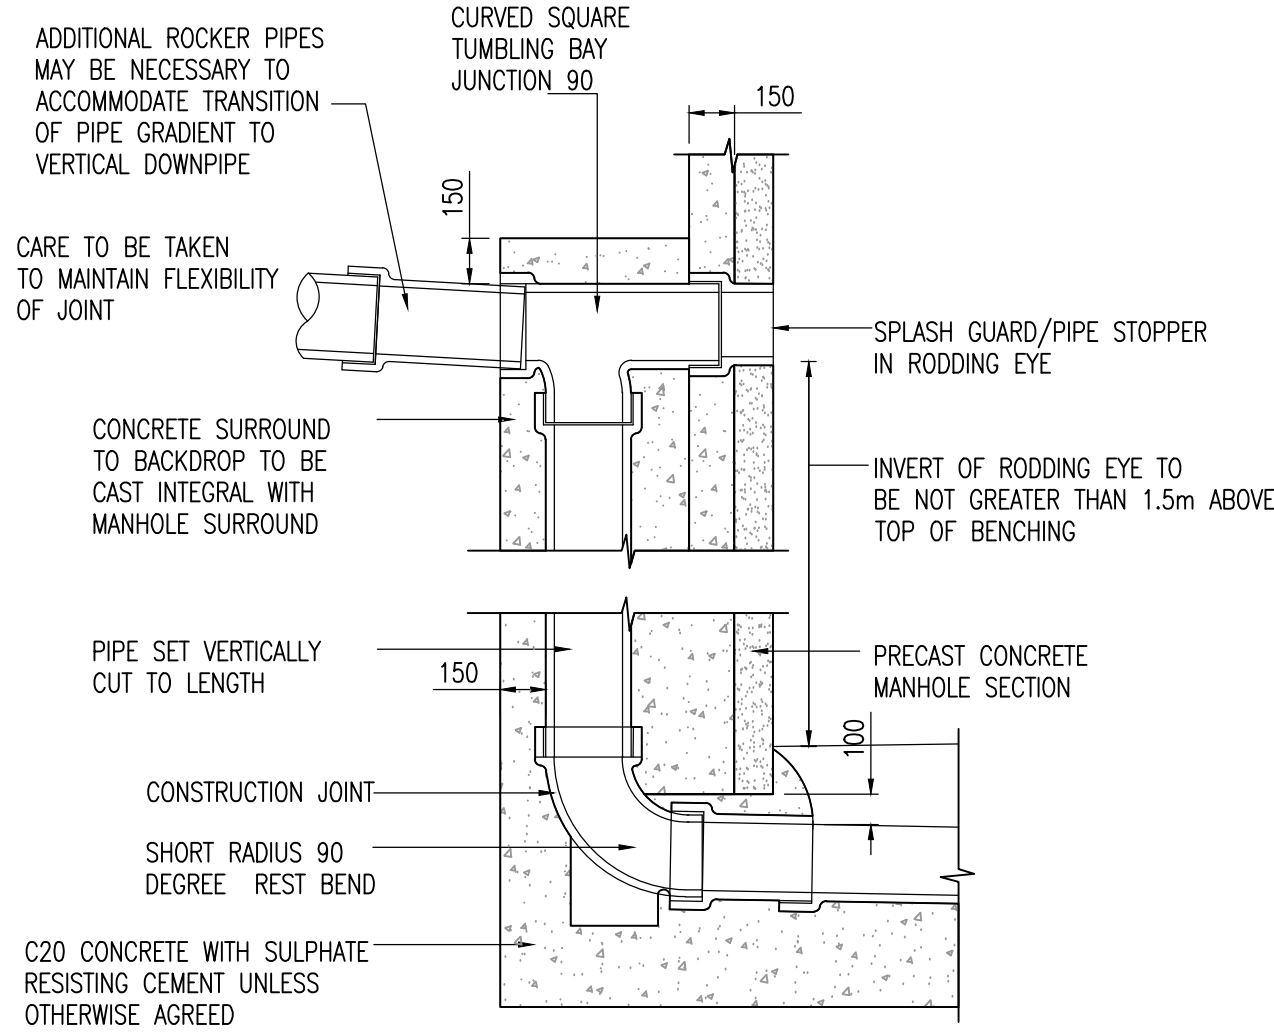


TYPICAL VERTICAL BACKDROP DETAIL

(1:25)

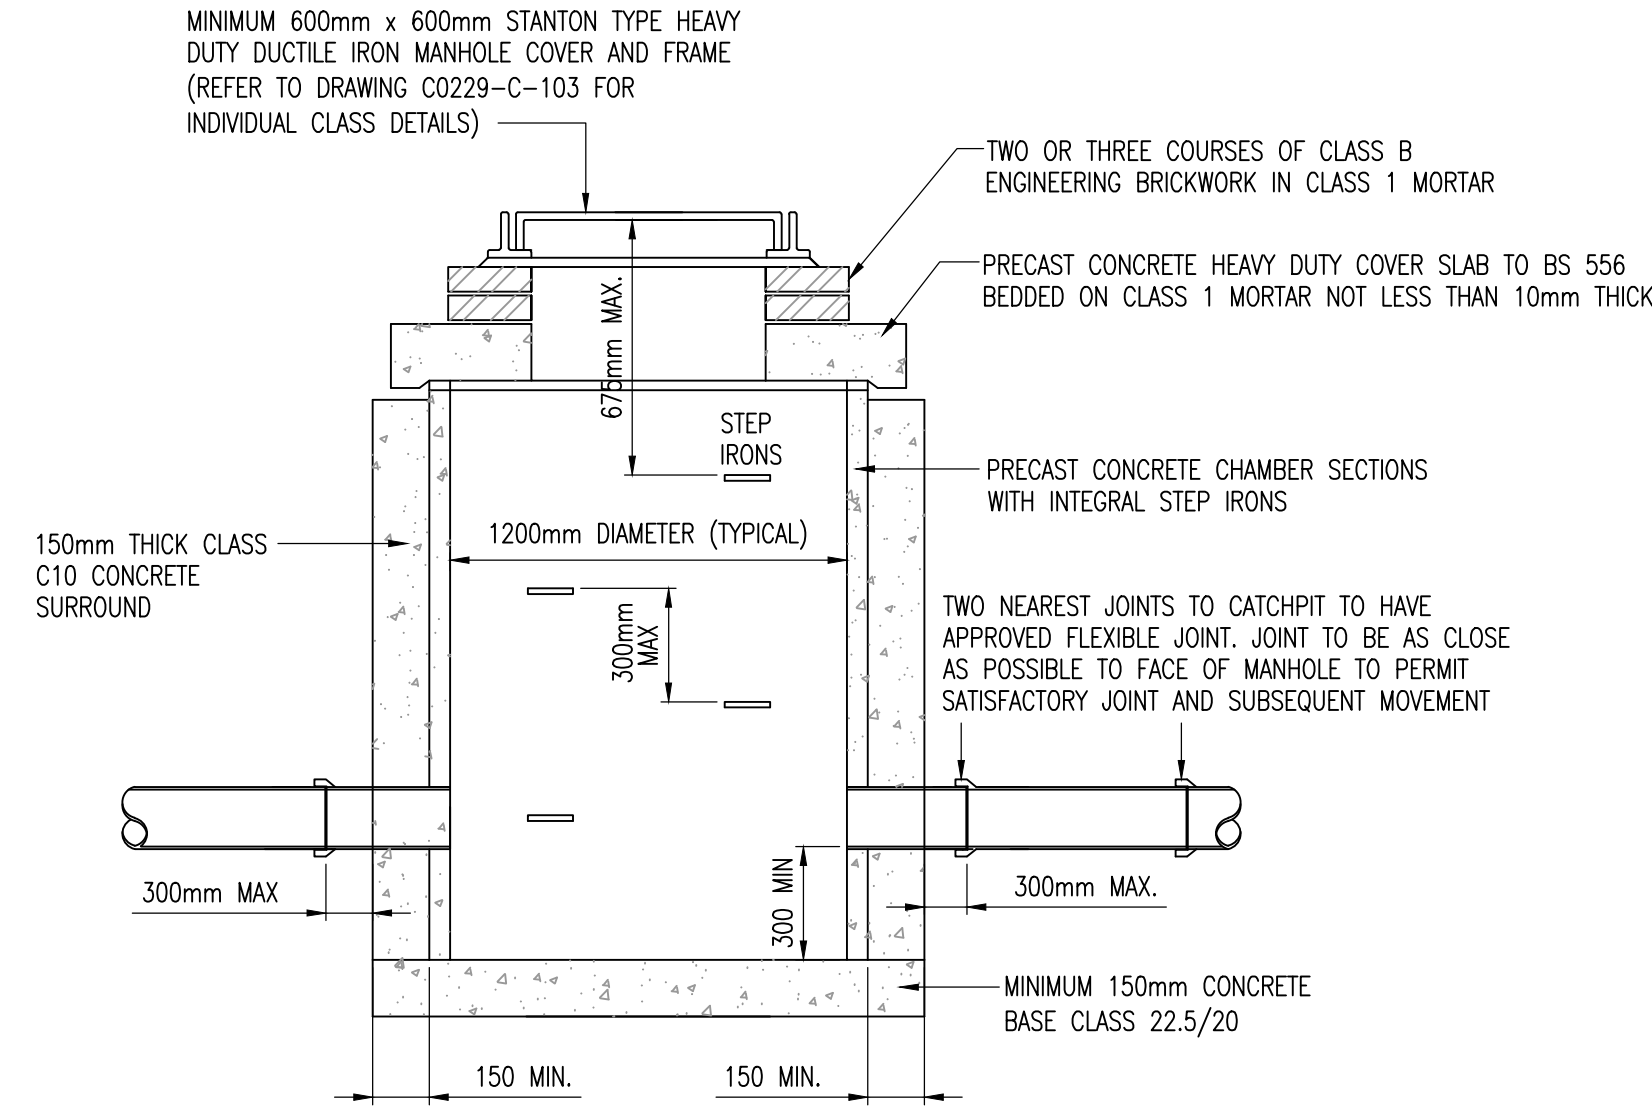


CATCHPIT MANHOLE

SCALE 1:20

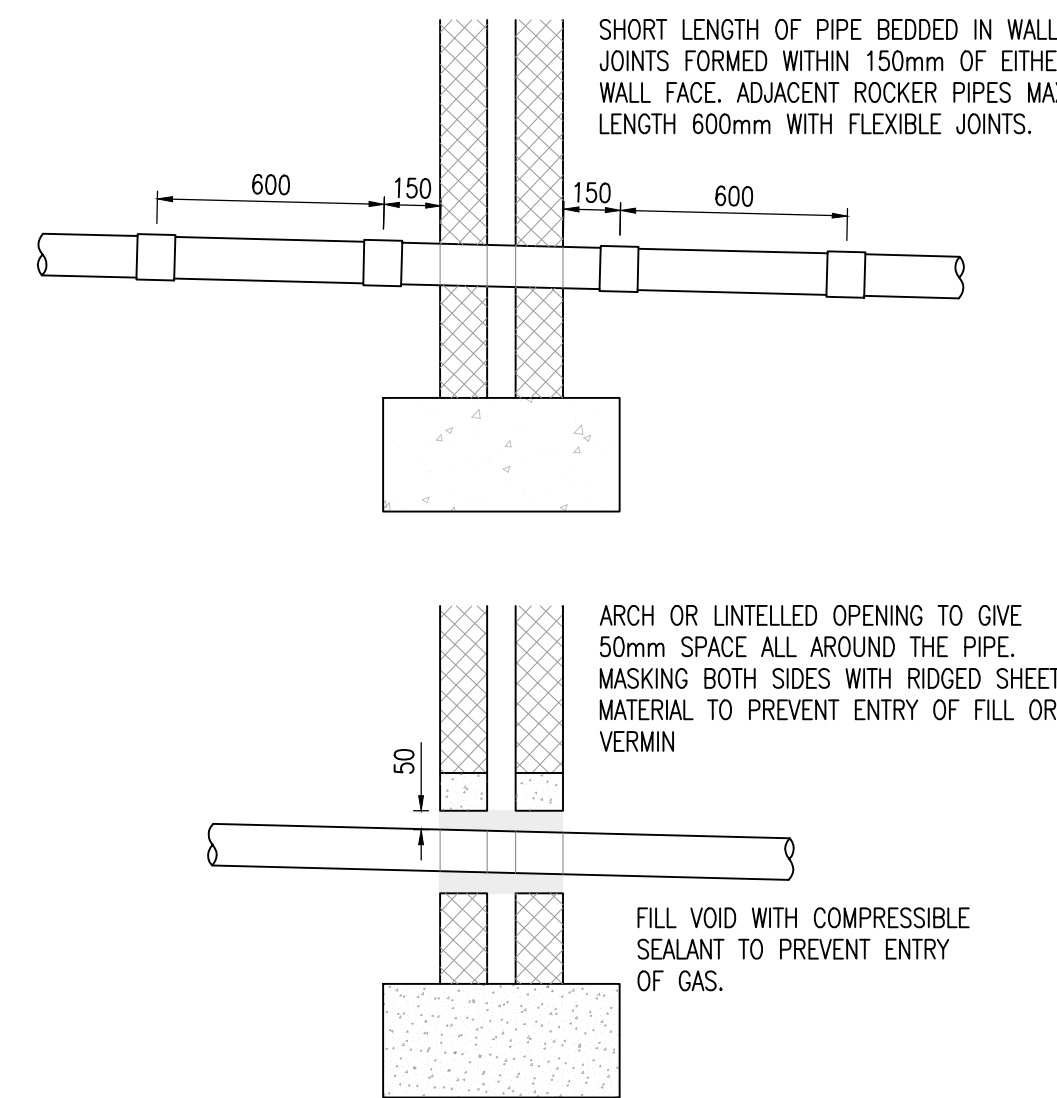

PIPES PENETRATING WALLS

(1:20)

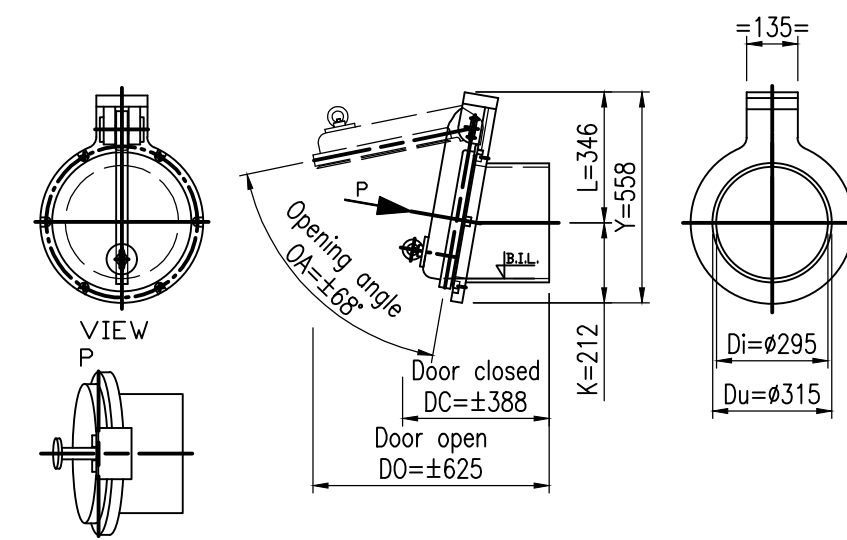

PTK-P PIPE MOUNTED FLAP NON RETURN VALVE OR SIMILAR APPROVED

(1:20)

GENERAL NOTES

1. CONTRACTOR TO CHECK ALL DIMENSIONS AND REPORT ALL ERRORS AND OMISSIONS TO THE ENGINEER.
2. ANY DISCREPANCY TO BE REPORTED IMMEDIATELY TO THE ENGINEER.
3. THIS DRAWING TO BE READ IN CONJUNCTION WITH ALL RELEVANT ARCHITECTS, SUBCONTRACTORS AND SPECIALISTS DRAWINGS AND SPECIFICATIONS.

DRAINAGE DESIGN AND CONSTRUCTION IN ACCORDANCE WITH SEWERS FOR ADOPTION 7TH EDITION AND THE REQUIREMENTS OF THE STATUTORY UNDERTAKER.

Rev.	Detail	By	Date
A	REMOVED 'DO NOT SCALE' NOTE	TE	07.07.22

Reinforcement schedules nos.



Structural & Civil Engineering Consultants

First Floor
7 St James Crescent
Swansea
SA1 4DP

Telephone +44 1792 473 182
e-mail admin@cb3consult.co.uk
web www.cb3consult.co.uk



Project

PROPOSED RESIDENTIAL DEVELOPMENT AT UTOXETER ROAD, UPPER TEAN

Drawing Title

DRAINAGE SHEET 2 OF 3

PRELIMINARY

Project No.		Drawing No.	
C1941		C-SK05	
Scales		Date	Revision
AS SHOWN		29.04.22	
Drawn	Checked	Sheet Size	A
DH	DF	A1	