



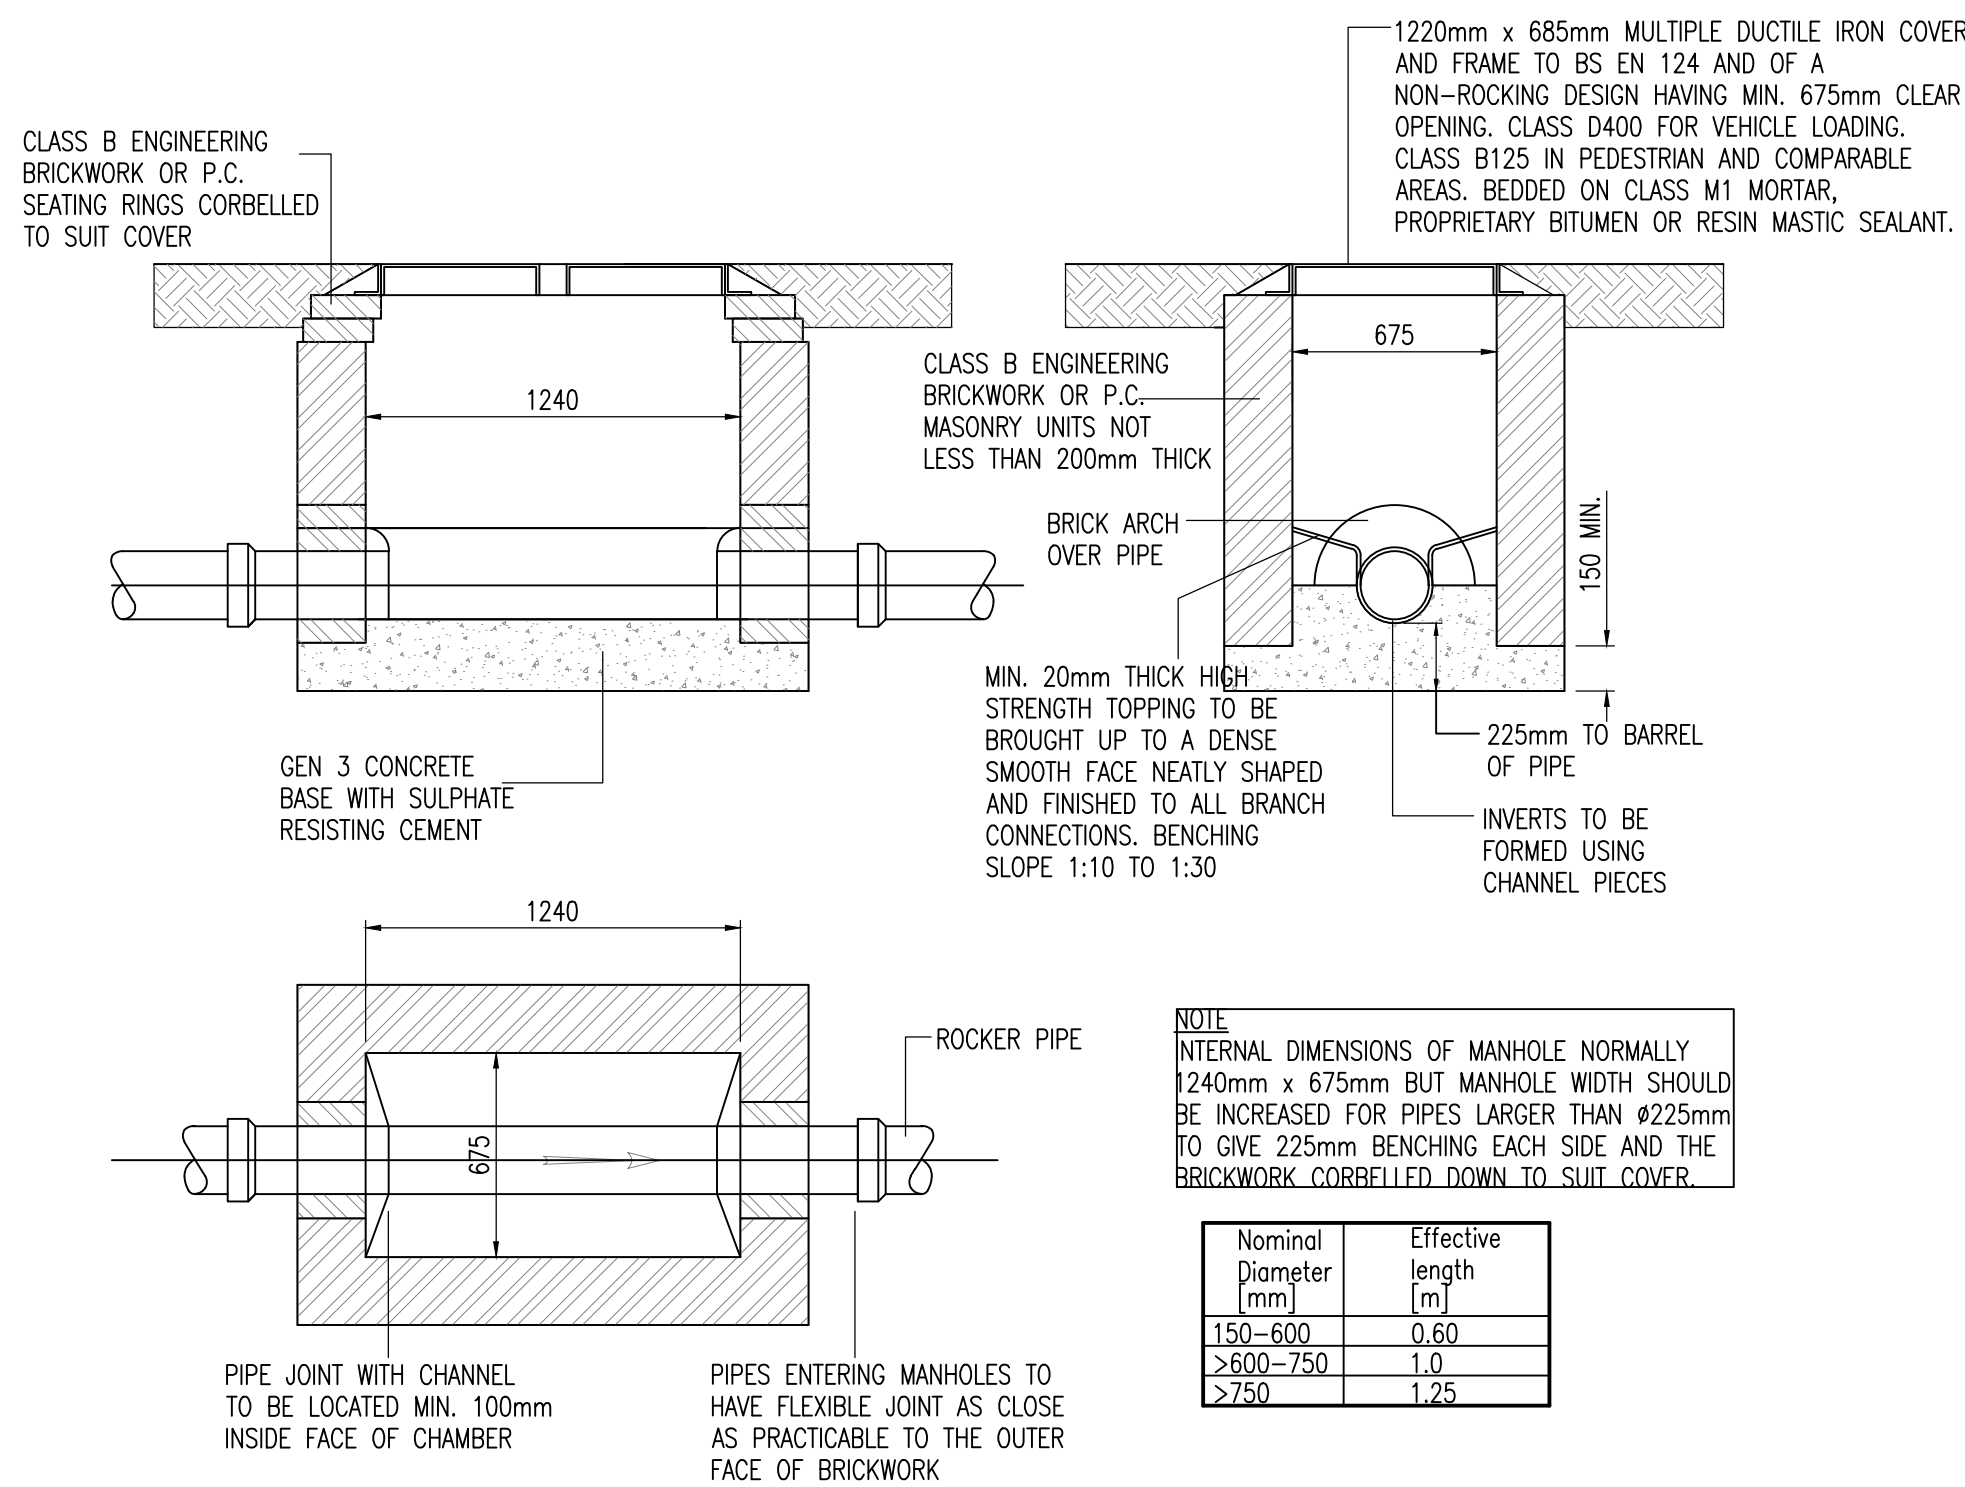

MANHOLE DETAIL – TYPE C
DEPTH TO SOFFIT OF PIPE 1.0m–1.5m
(1:25)

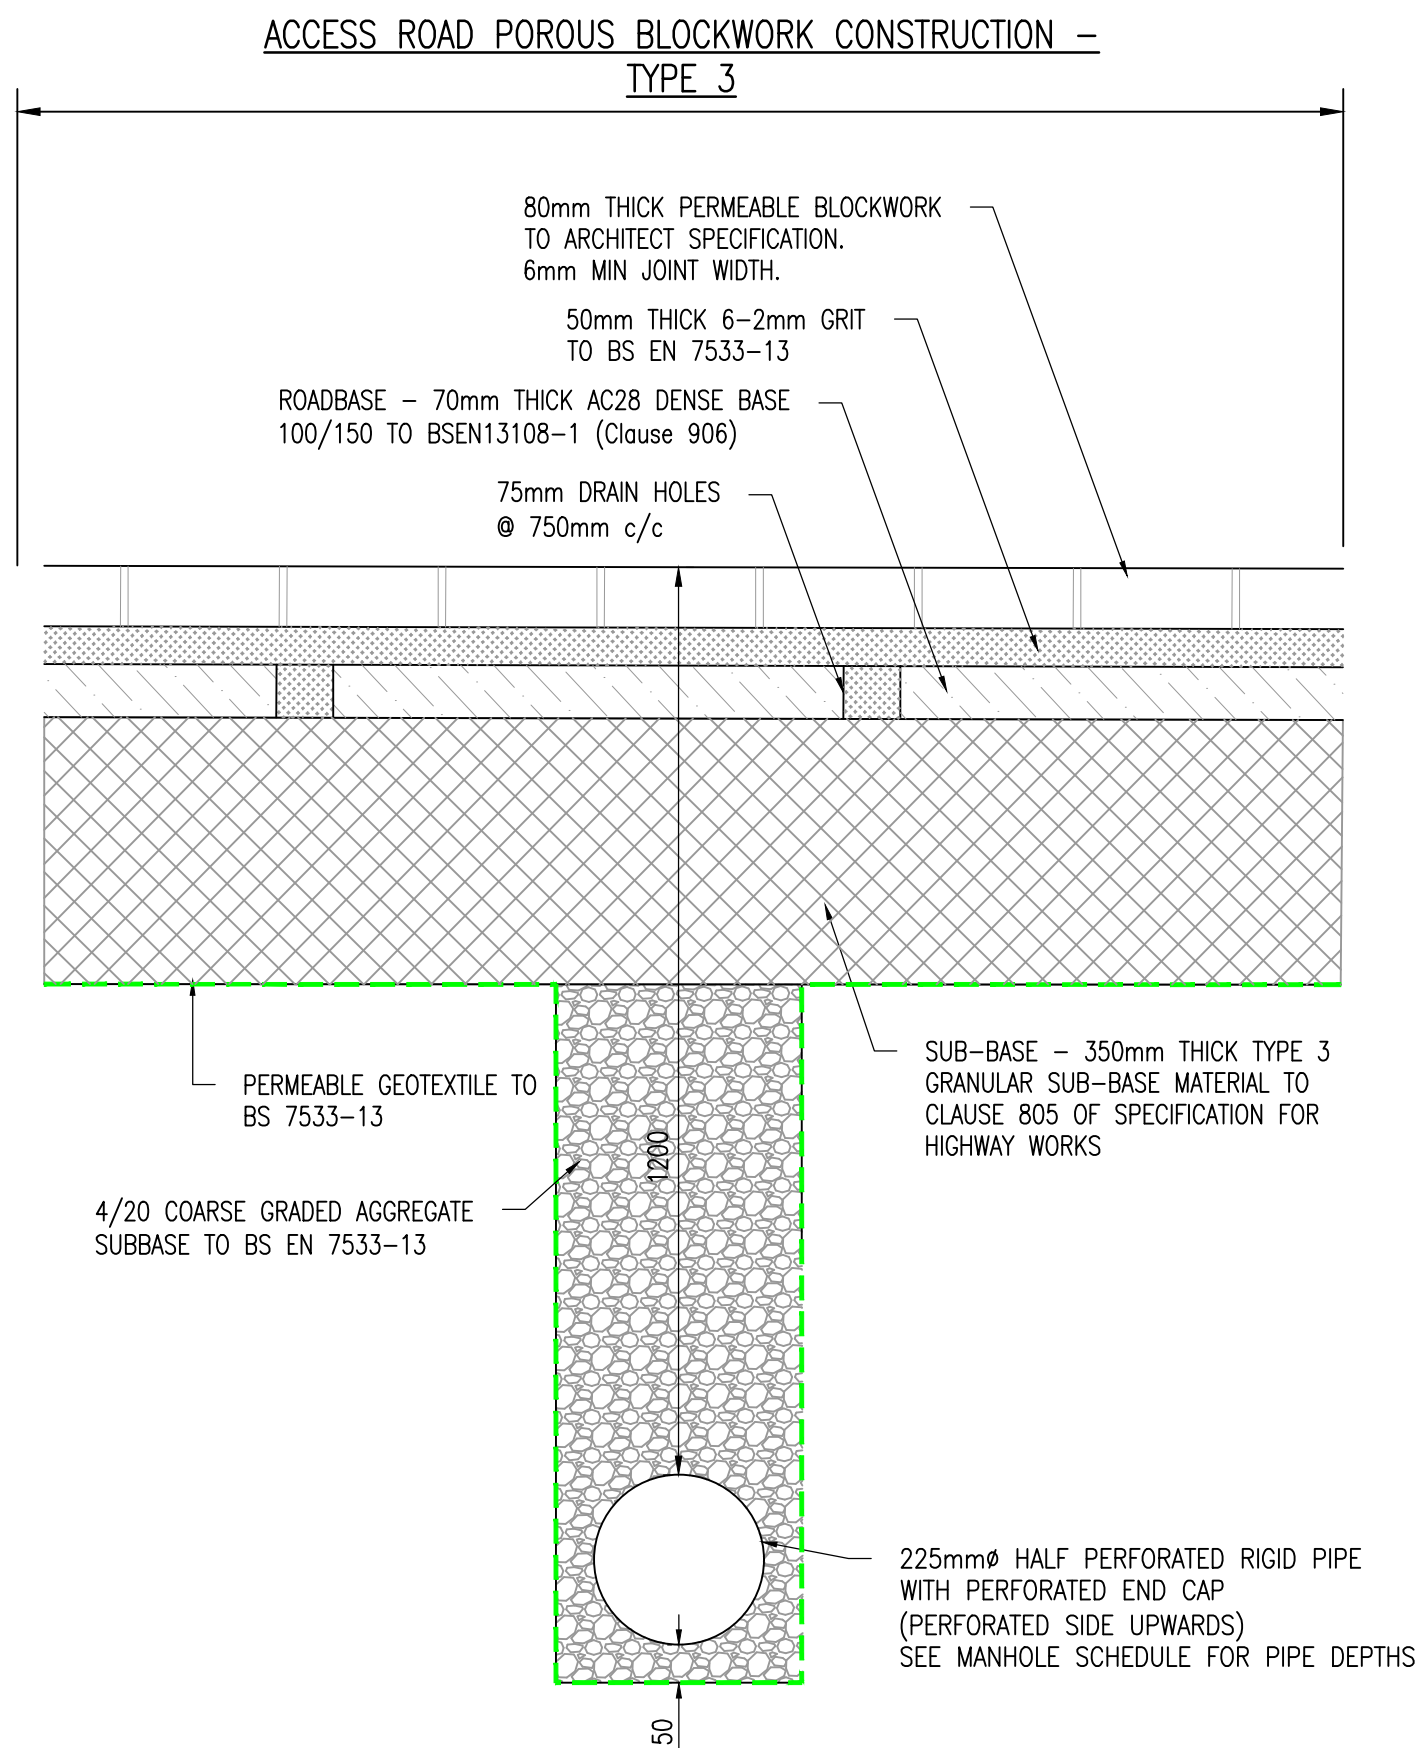

GENERAL NOTES

- CONTRACTOR TO CHECK ALL DIMENSIONS AND REPORT ALL ERRORS AND OMISSIONS TO THE ENGINEER.
- ANY DISCREPANCY TO BE REPORTED IMMEDIATELY TO THE ENGINEER.
- THIS DRAWING TO BE READ IN CONJUNCTION WITH ALL RELEVANT ARCHITECTS, SUBCONTRACTORS AND SPECIALISTS DRAWINGS AND SPECIFICATIONS.

Rev. Detail By Date

Revisions

Reinforcement schedules nos.



Structural & Civil Engineering Consultants

First Floor
7 St James Crescent
Swansea
SA1 6DP

Telephone +44 1792 473 182
e-mail admin@cb3consult.co.uk
web www.cb3consult.co.uk



Project
PROPOSED RESIDENTIAL
DEVELOPMENT AT
UTTOXETER ROAD,
UPPER TEAN

Drawing Title
DRAINAGE
SHEET 4 OF 4

PRELIMINARY

Project No. C1941		Drawing No. C-SK12	
Scales AS SHOWN		Date 29.04.22	Revision
Drawn DH	Checked DF	Sheet Size A1	—