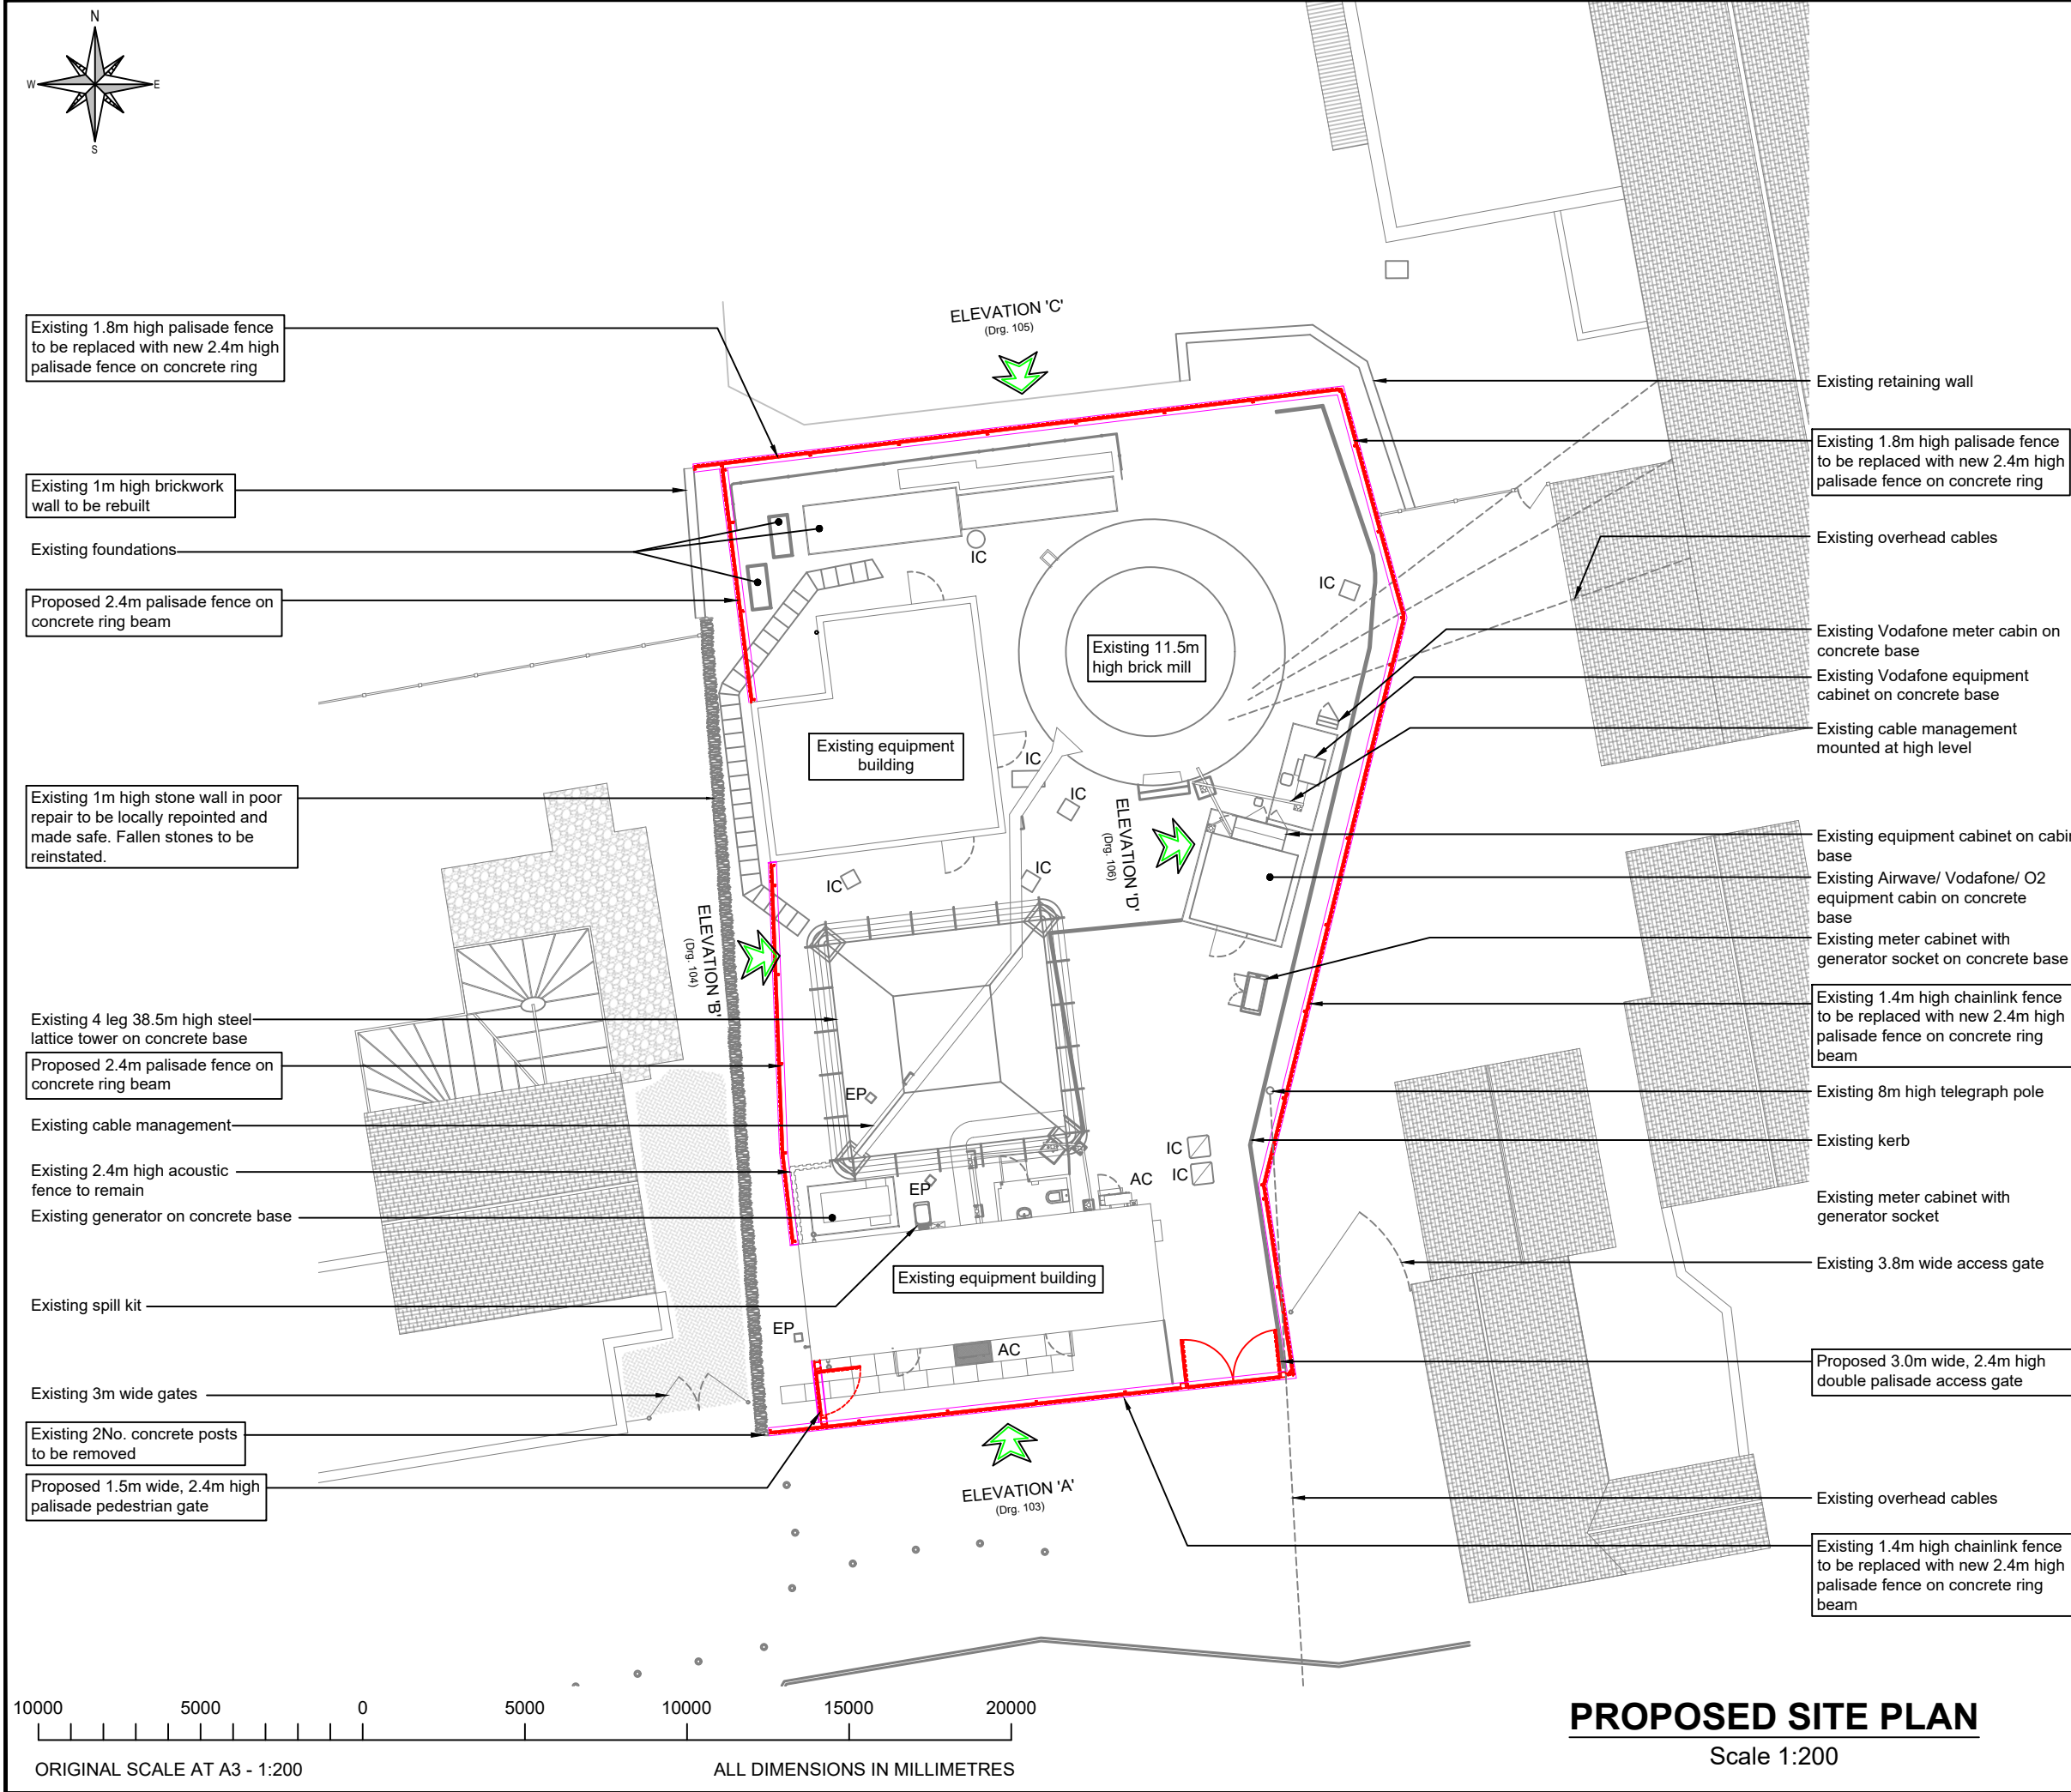


AC = Air Conditioning Unit
IC = Inspection Chamber
EP = Earth Pit

Proposed palisade fence to be painted green

A	Planning Issue	29.11.24	VV
Rev	Description	Date	By

National Grid Telecoms Ltd
Avon Bank
Feeder Road
Bristol BS2 0TB

TBC

WERRINGTON

PROPOSED FENCE

ASH BANK RD (A52)
WERRINGTON
STAFFORDSHIRE
ST9 0DU

PROPOSED SITE PLAN

Scale:	Drawn: VV	Checked: RJW
As Shown	Date: 29.11.24	Date: 29.11.24

Drawing No.	Rev.	Pack Issue
P1628-064-1-PL-203	A	A

Scale 1:200