




1. THIS DRAWING TO BE READ IN CONJUNCTION WITH ALL RELEVANT ENGINEERS AND SPECIALISTS DRAWINGS & SPECIFICATIONS.
2. ANY DISCREPANCIES BETWEEN THIS DRAWING AND ANY OTHER TO BE REPORTED TO THE ENGINEER IMMEDIATELY.
3. ALL WORKS TO COMPLY WITH THE MOST CURRENT BRITISH STANDARDS.
4. ALL DIMENSIONS IN MILLIMETERS UNLESS STATED OTHERWISE. USE FIGURED DIMENSIONS ONLY.
5. ALL DIMENSIONS TO BE $\pm 3\text{mm}$ UNLESS SPECIFIED OTHERWISE.
6. A RECESSIVE COLOUR SUCH AS GREY IS PROPOSED, BUT CAN BE AGREED WITH OFFICERS.

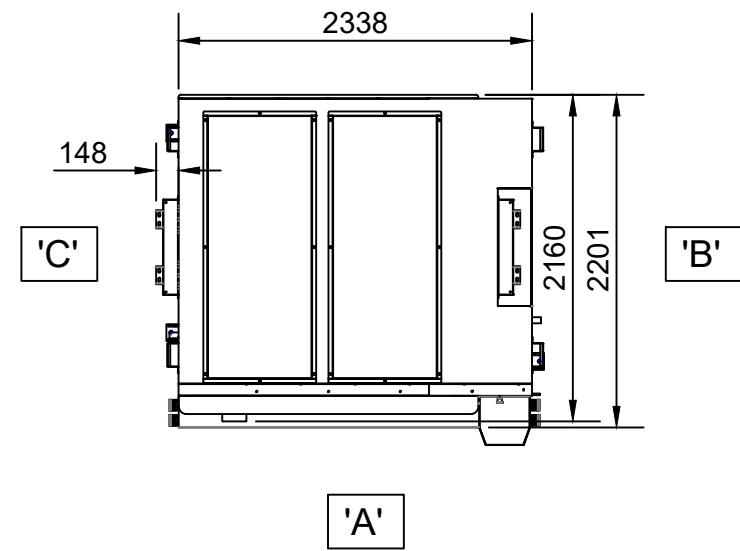


PLAN VIEW

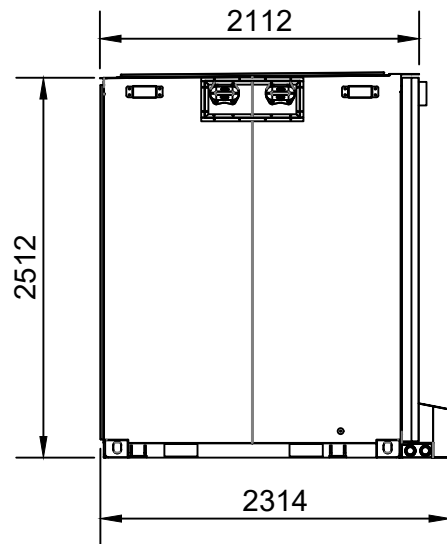

SIDE ELEVATION 'C'

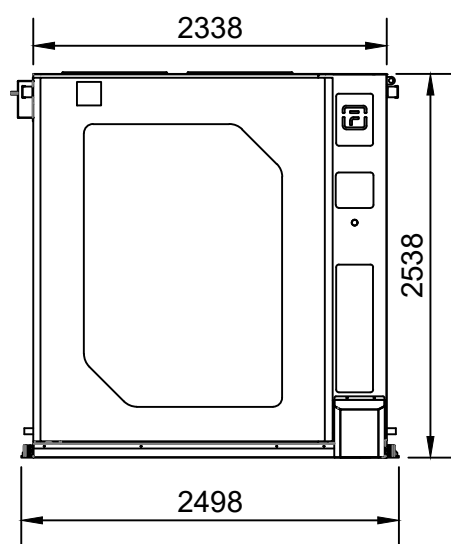


FRONT ELEVATION 'A'

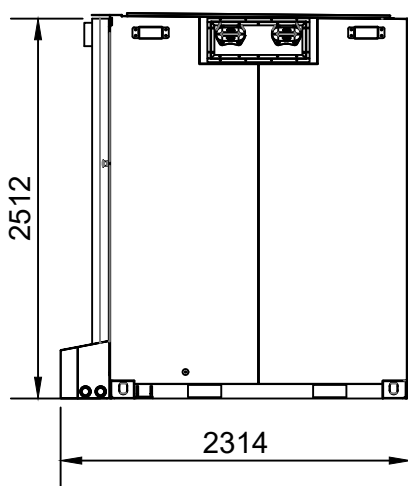


SIDE ELEVATION 'B'

BESS UNIT FLUENCE CUBE

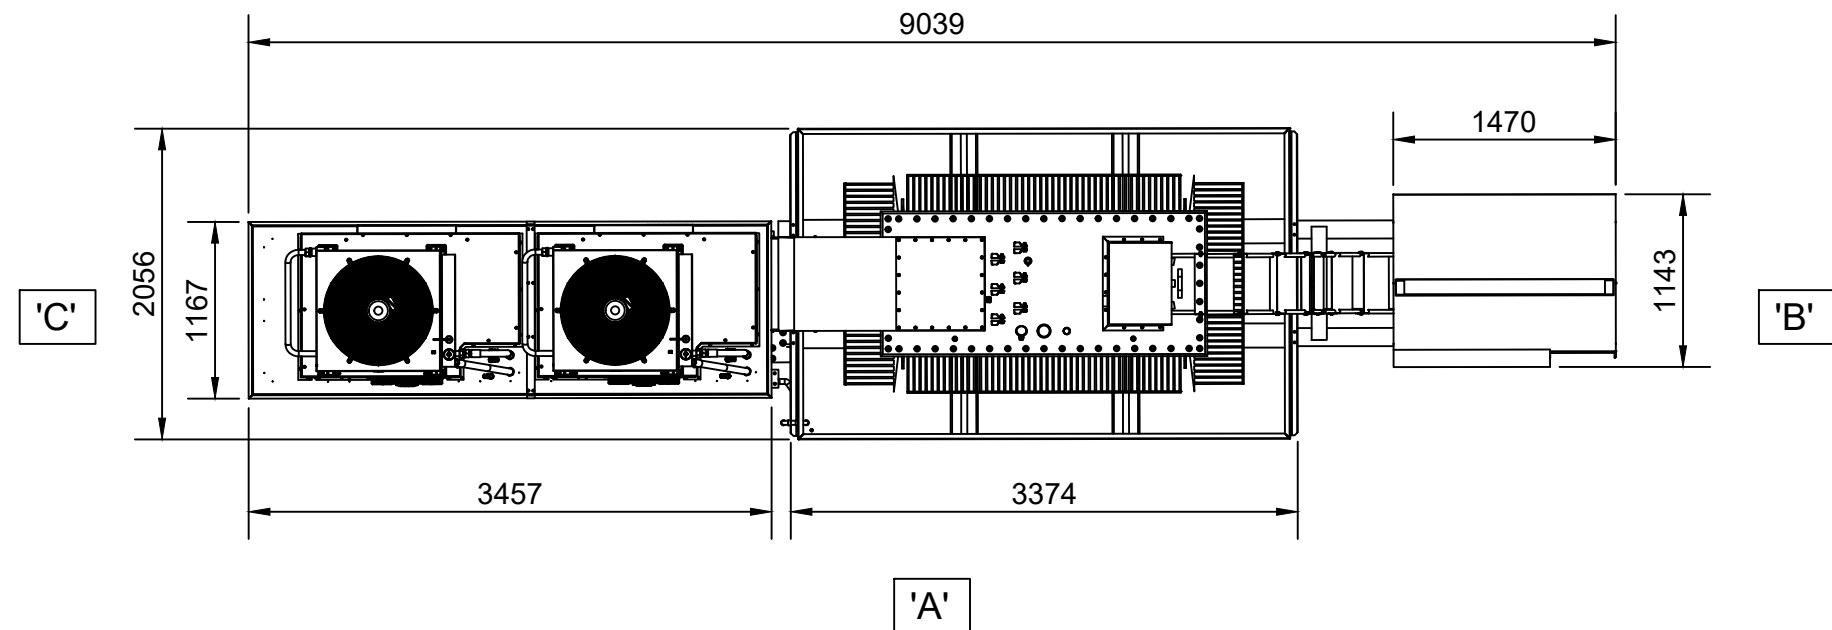


PLAN VIEW


MV SKID SOLUTION - INVERTER + TRANSFORMER

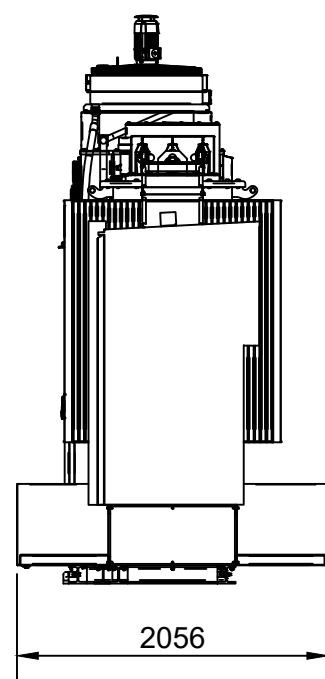


SIDE ELEVATION 'C'

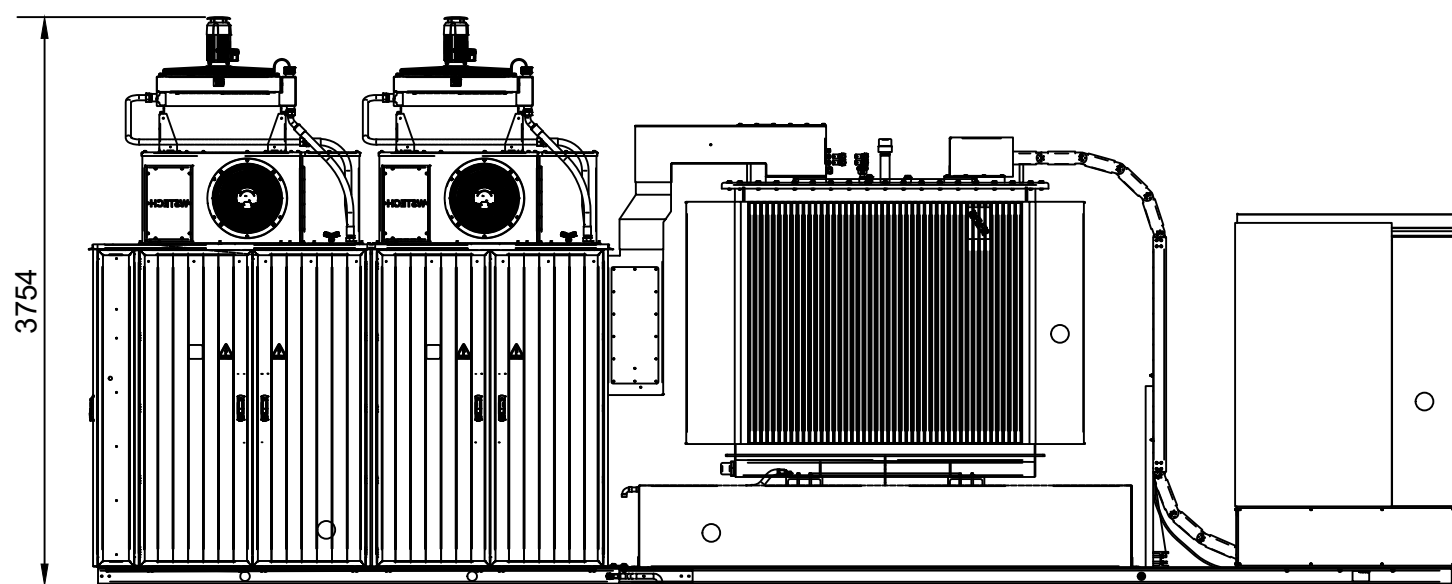

FRONT ELEVATION 'A'

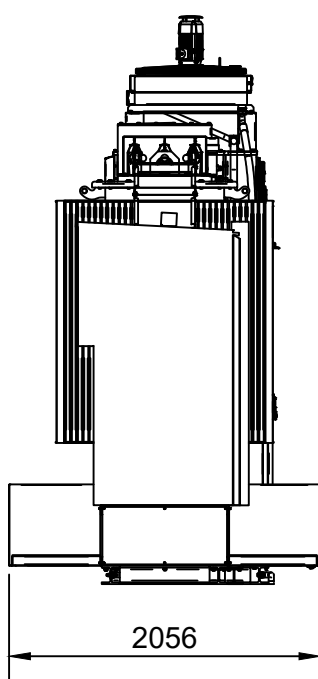

SIDE ELEVATION 'B'

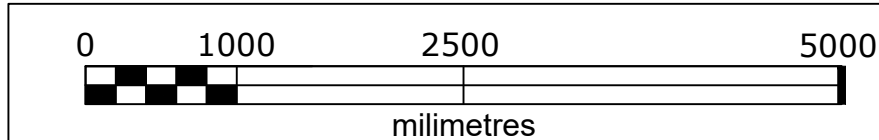

Project: Newfields Farm BESS					
Drawing name: Plan and Elevations of BESS Units and MV SKID Solution					
ID:	88-10-05-P-PL-EQ-03			Drawn:	REN
R.05	Dimensions Checked			02.04.2024	
R.04	Text Related to Scaling Modified			19.01.2024	
R.03	Elevations Modified			13.03.2023	
R.02	Scale Bar Added			05.10.2022	
R.01	Scale 1:50			20.04.2022	
R.00	First Issue			21.03.2022	
Revision	Description			Date	
Discipline:	Electrical	Phase:	FOR PLANNING	Format:	A1
		Scale:	1:50	Sheet No:	01 / 01
Client: RE Project Development Limited					
		RENERGY LTD			
		28 E Samokov str. 1113 Sofia, Bulgaria info@renergy-bg.com www.renergy-bg.com			
This drawing may not be reproduced or be made available to third person or competing companies without Renergy permission. The reproduction, distribution and utilization of this document as well as the communication of its contents without explicit authorization is prohibited. Offenders will be held liable and can find up to 50% of the project cost, variations in design can occur to site conditions.					