


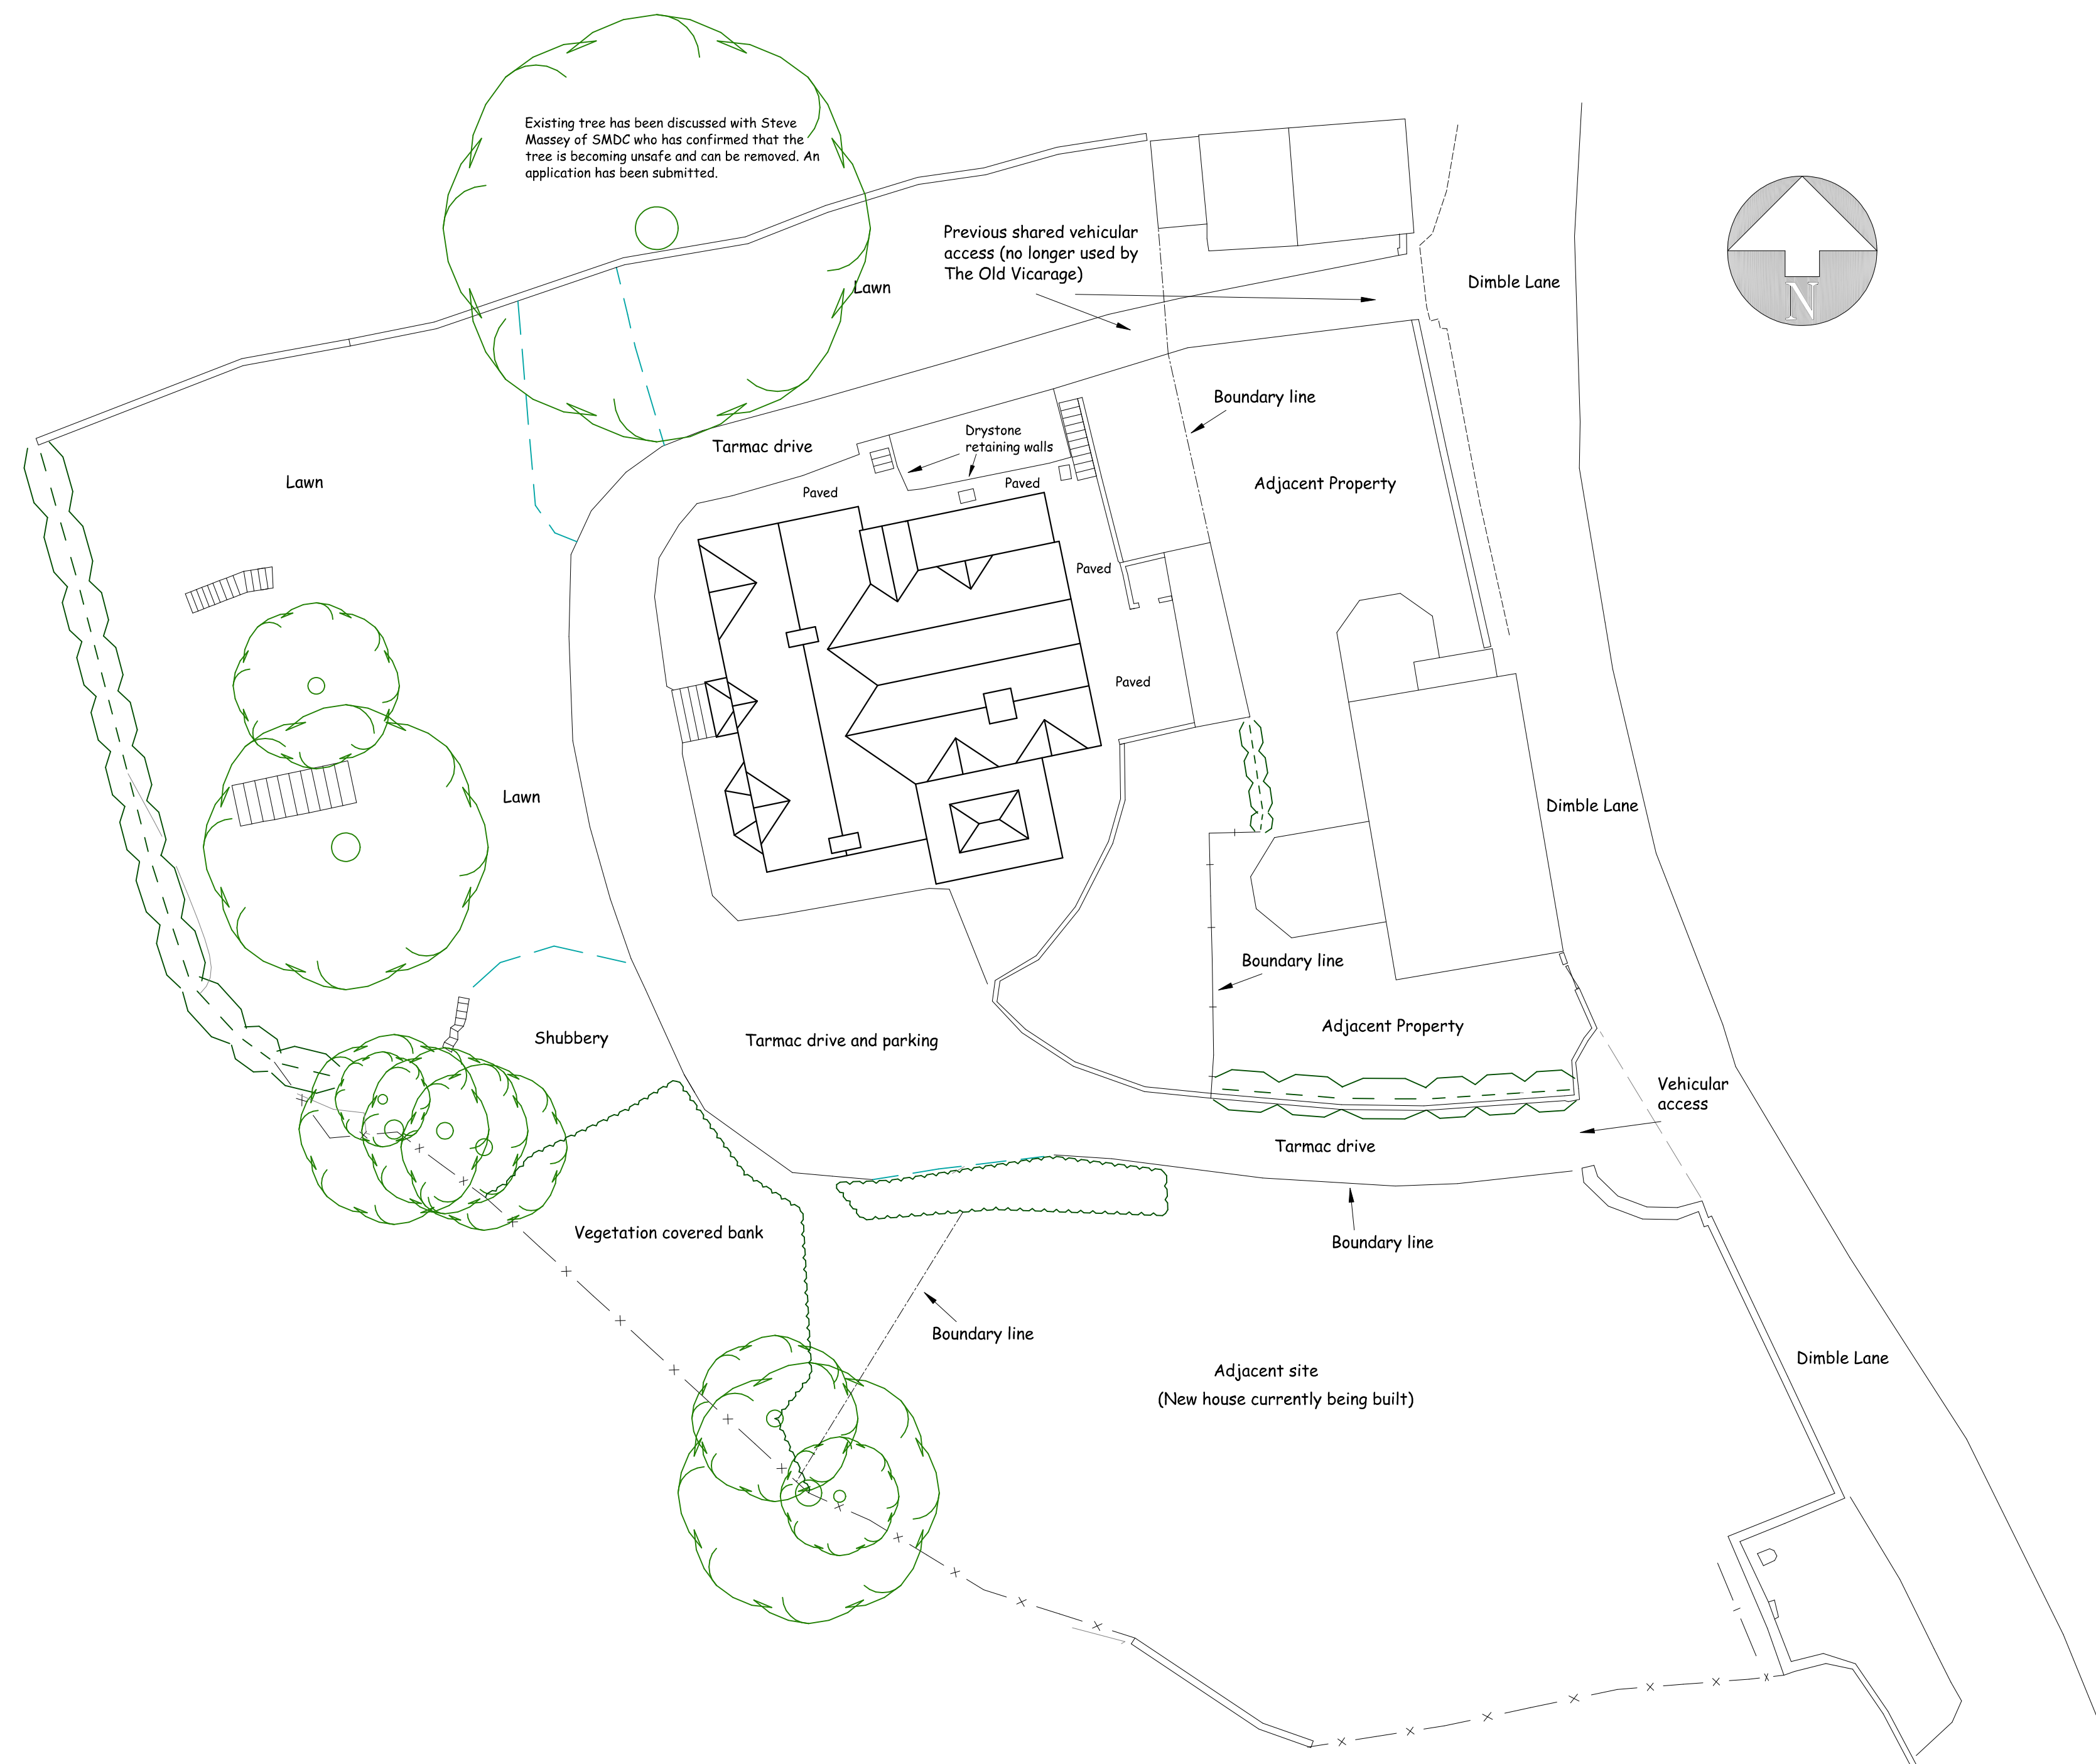

Nigel Forrester MCIQB  
Building Design Services

CLIENT

PROJECT

DRAWING NUMBER 25/707/02

### Location & existing site plan

SCALES      1/200 & 1/1250 @ A1