


Work to annotated dimensions only. Harrison Ince take no responsibility from any inaccuracies from scaling from this drawing.
All dimensions to be checked on site prior to manufacture and construction. This drawing is the property of Harrison Ince Holdings Limited and should not be reproduced without permission.
All discrepancies to be brought to the attention of the architect immediately.
This drawing is to be read in conjunction with the specification / bill of quantities and related drawings.

REVISIONS

FIRST ISSUE

09.04.2025 FA

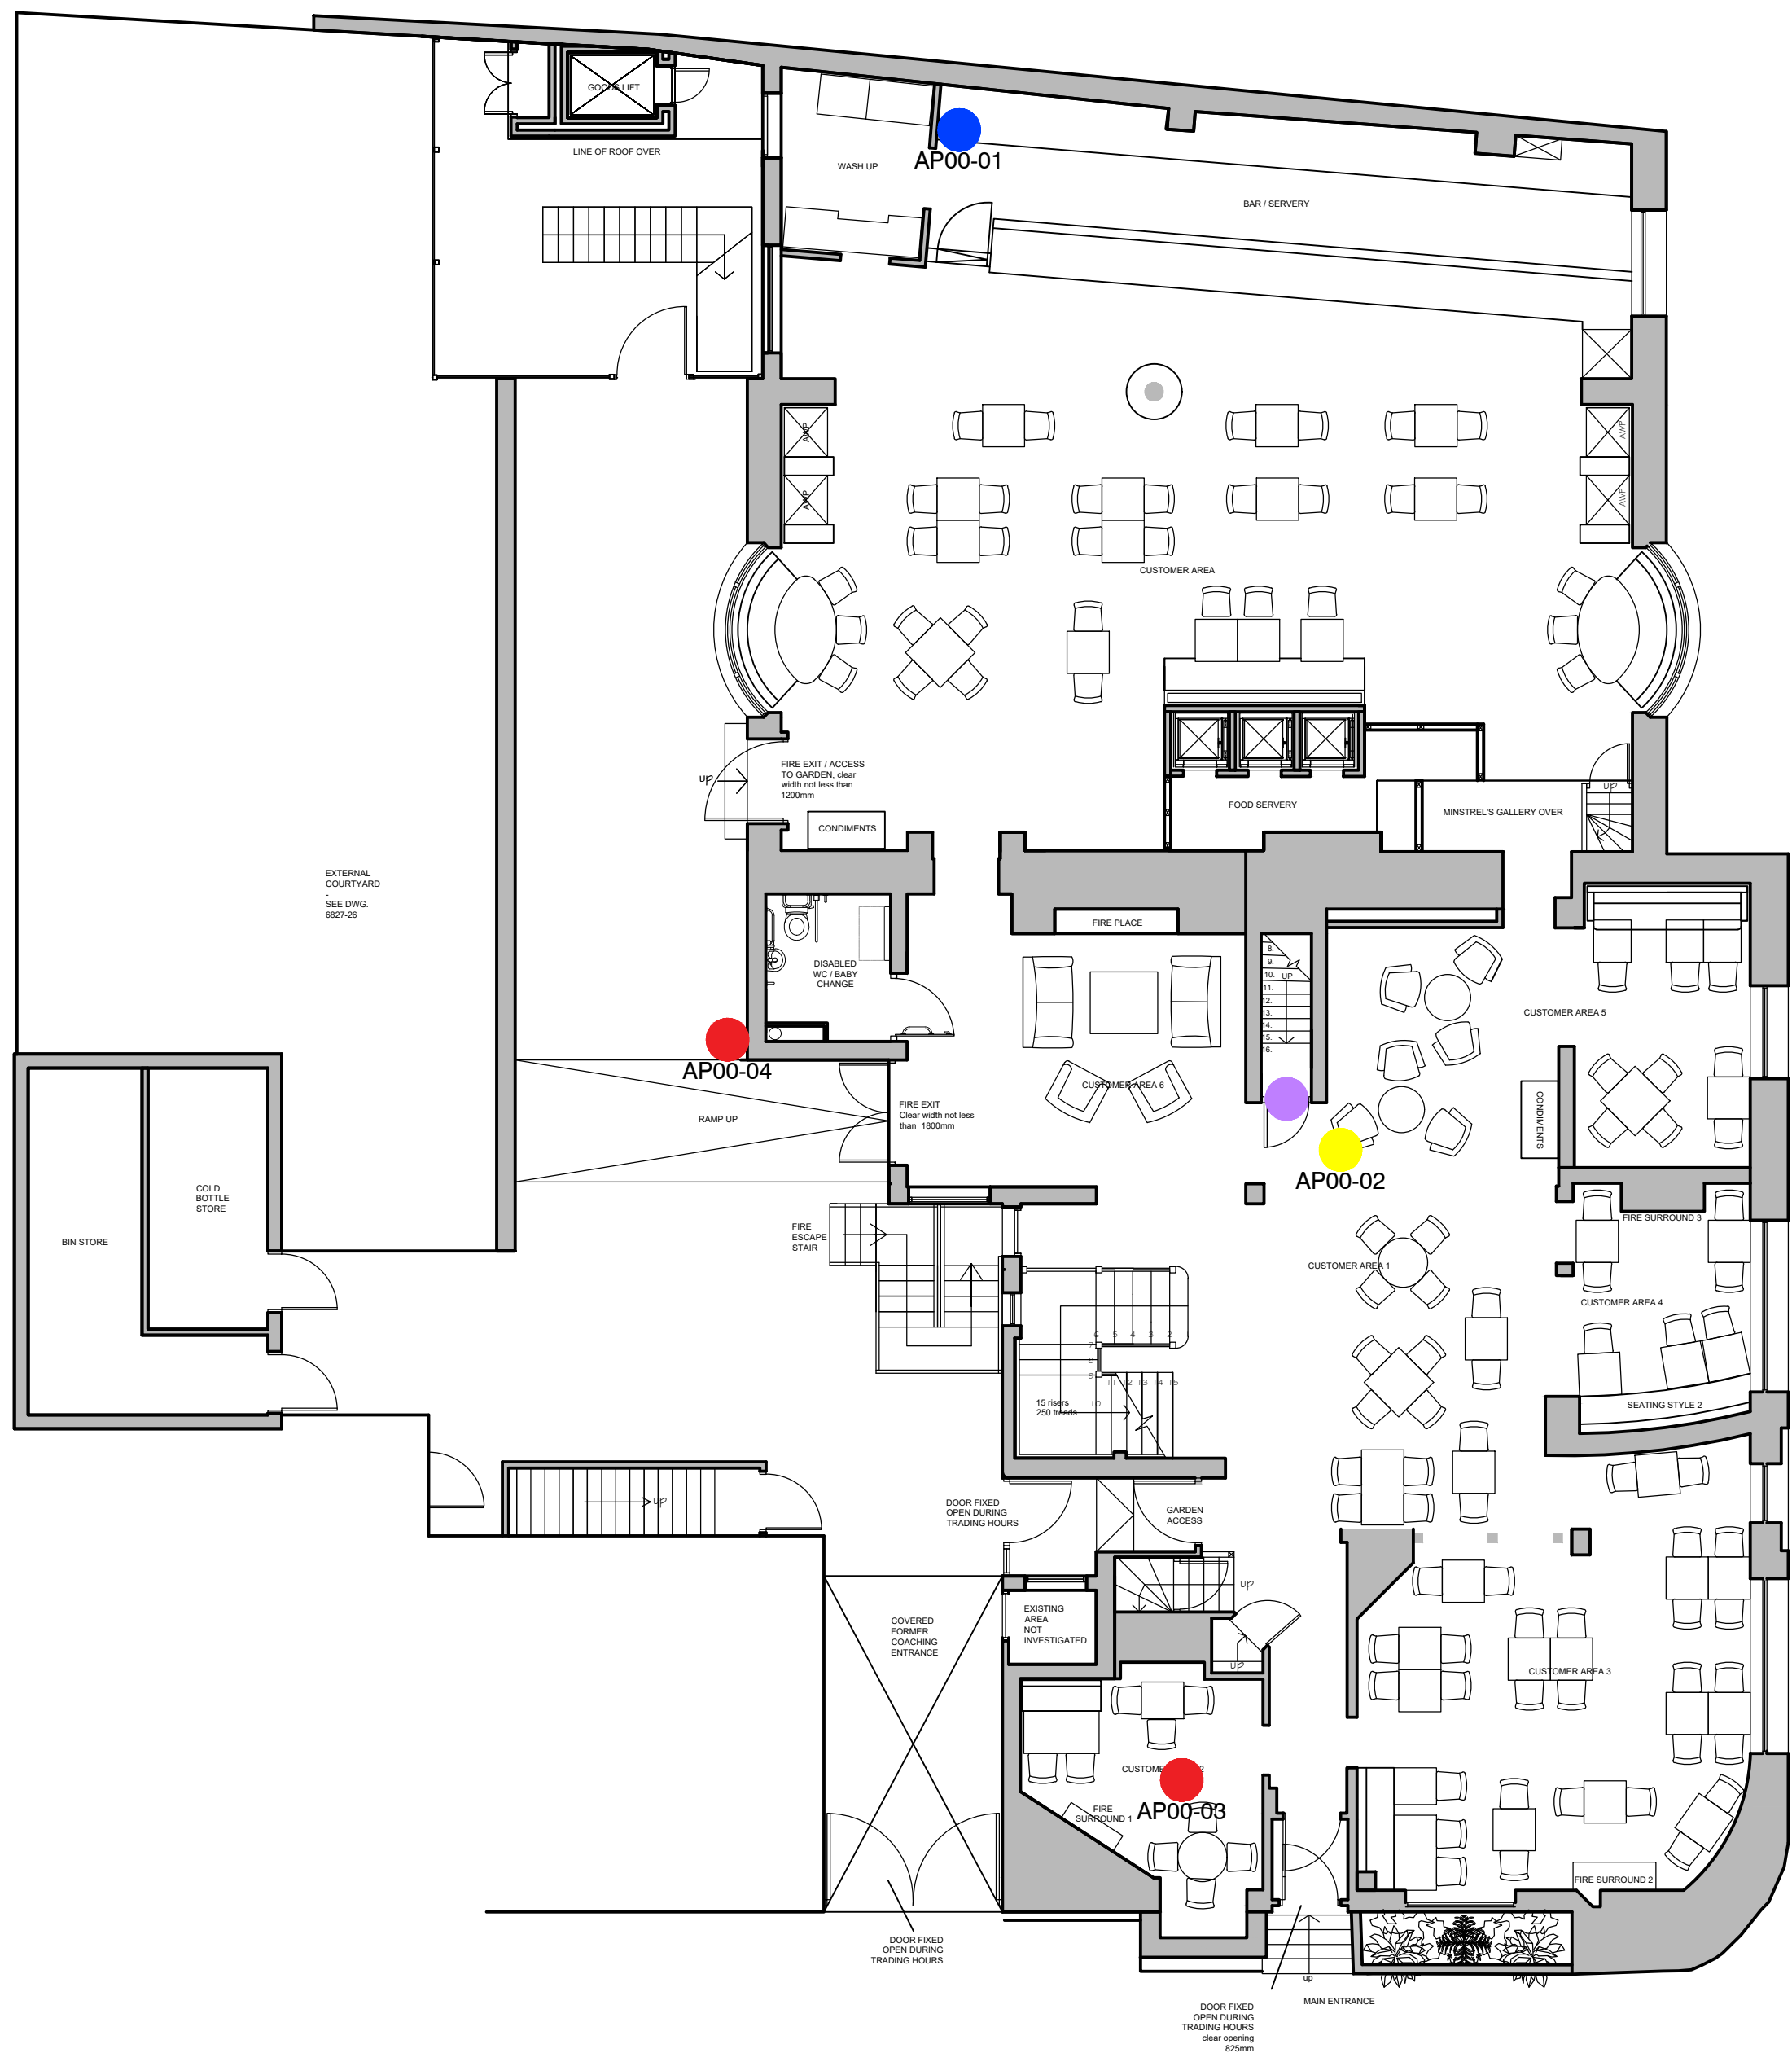

LEGEND

- CABLE ROUTE
- ADDITIONAL WIRELESS ACCESS POINTS
- EXISTING WIRELESS ACCESS POINTS
- WIRELESS ACCESS POINTS TO RELOCATE (PROPOSED LOCATION)
- WIRELESS ACCESS POINTS TO RELOCATE (EXISTING LOCATION)
- FORTINET 4G DEVICE

@1:100 scale



PROPOSED GROUND FLOOR PLAN
Scale 1:100



HARRISON INCE

ARCHITECTS INTERIOR DESIGNERS

JD WETHERSPOON

CLIENT

THE GREEN DRAGON, 2 ST EDWARD ST,
LEEK, ST13 5DS

PROJECT

PROPOSED GROUND FLOOR PLAN

TITLE

DATE APRIL 2025

SCALE 1:100 @ A1

JOB NO.

PN7029

DWGS. NO.

AL01

DRAWN

CAD/FA

CHECKED

SECOND FLOOR
EASTGATE
2 CASTLE STREET
MANCHESTER
M14 4JZ
TEL: 0161 236 3650
EMAIL: admin@harrison-ince.co.uk