



REVISIONS	Work to annotated dimensions only. Harrison Ince take no responsibility from any inaccuracies from scaling from this drawing. All dimensions to be checked on site prior to manufacture and construction. This drawing is the property of Harrison Ince Holdings Limited and should not be reproduced without permission. All discrepancies to be brought to the attention of the architect immediately. This drawing is to be read in conjunction with the specification / bill of quantities and related drawings.		
	-	FIRST ISSUE	09.04.2025 FA

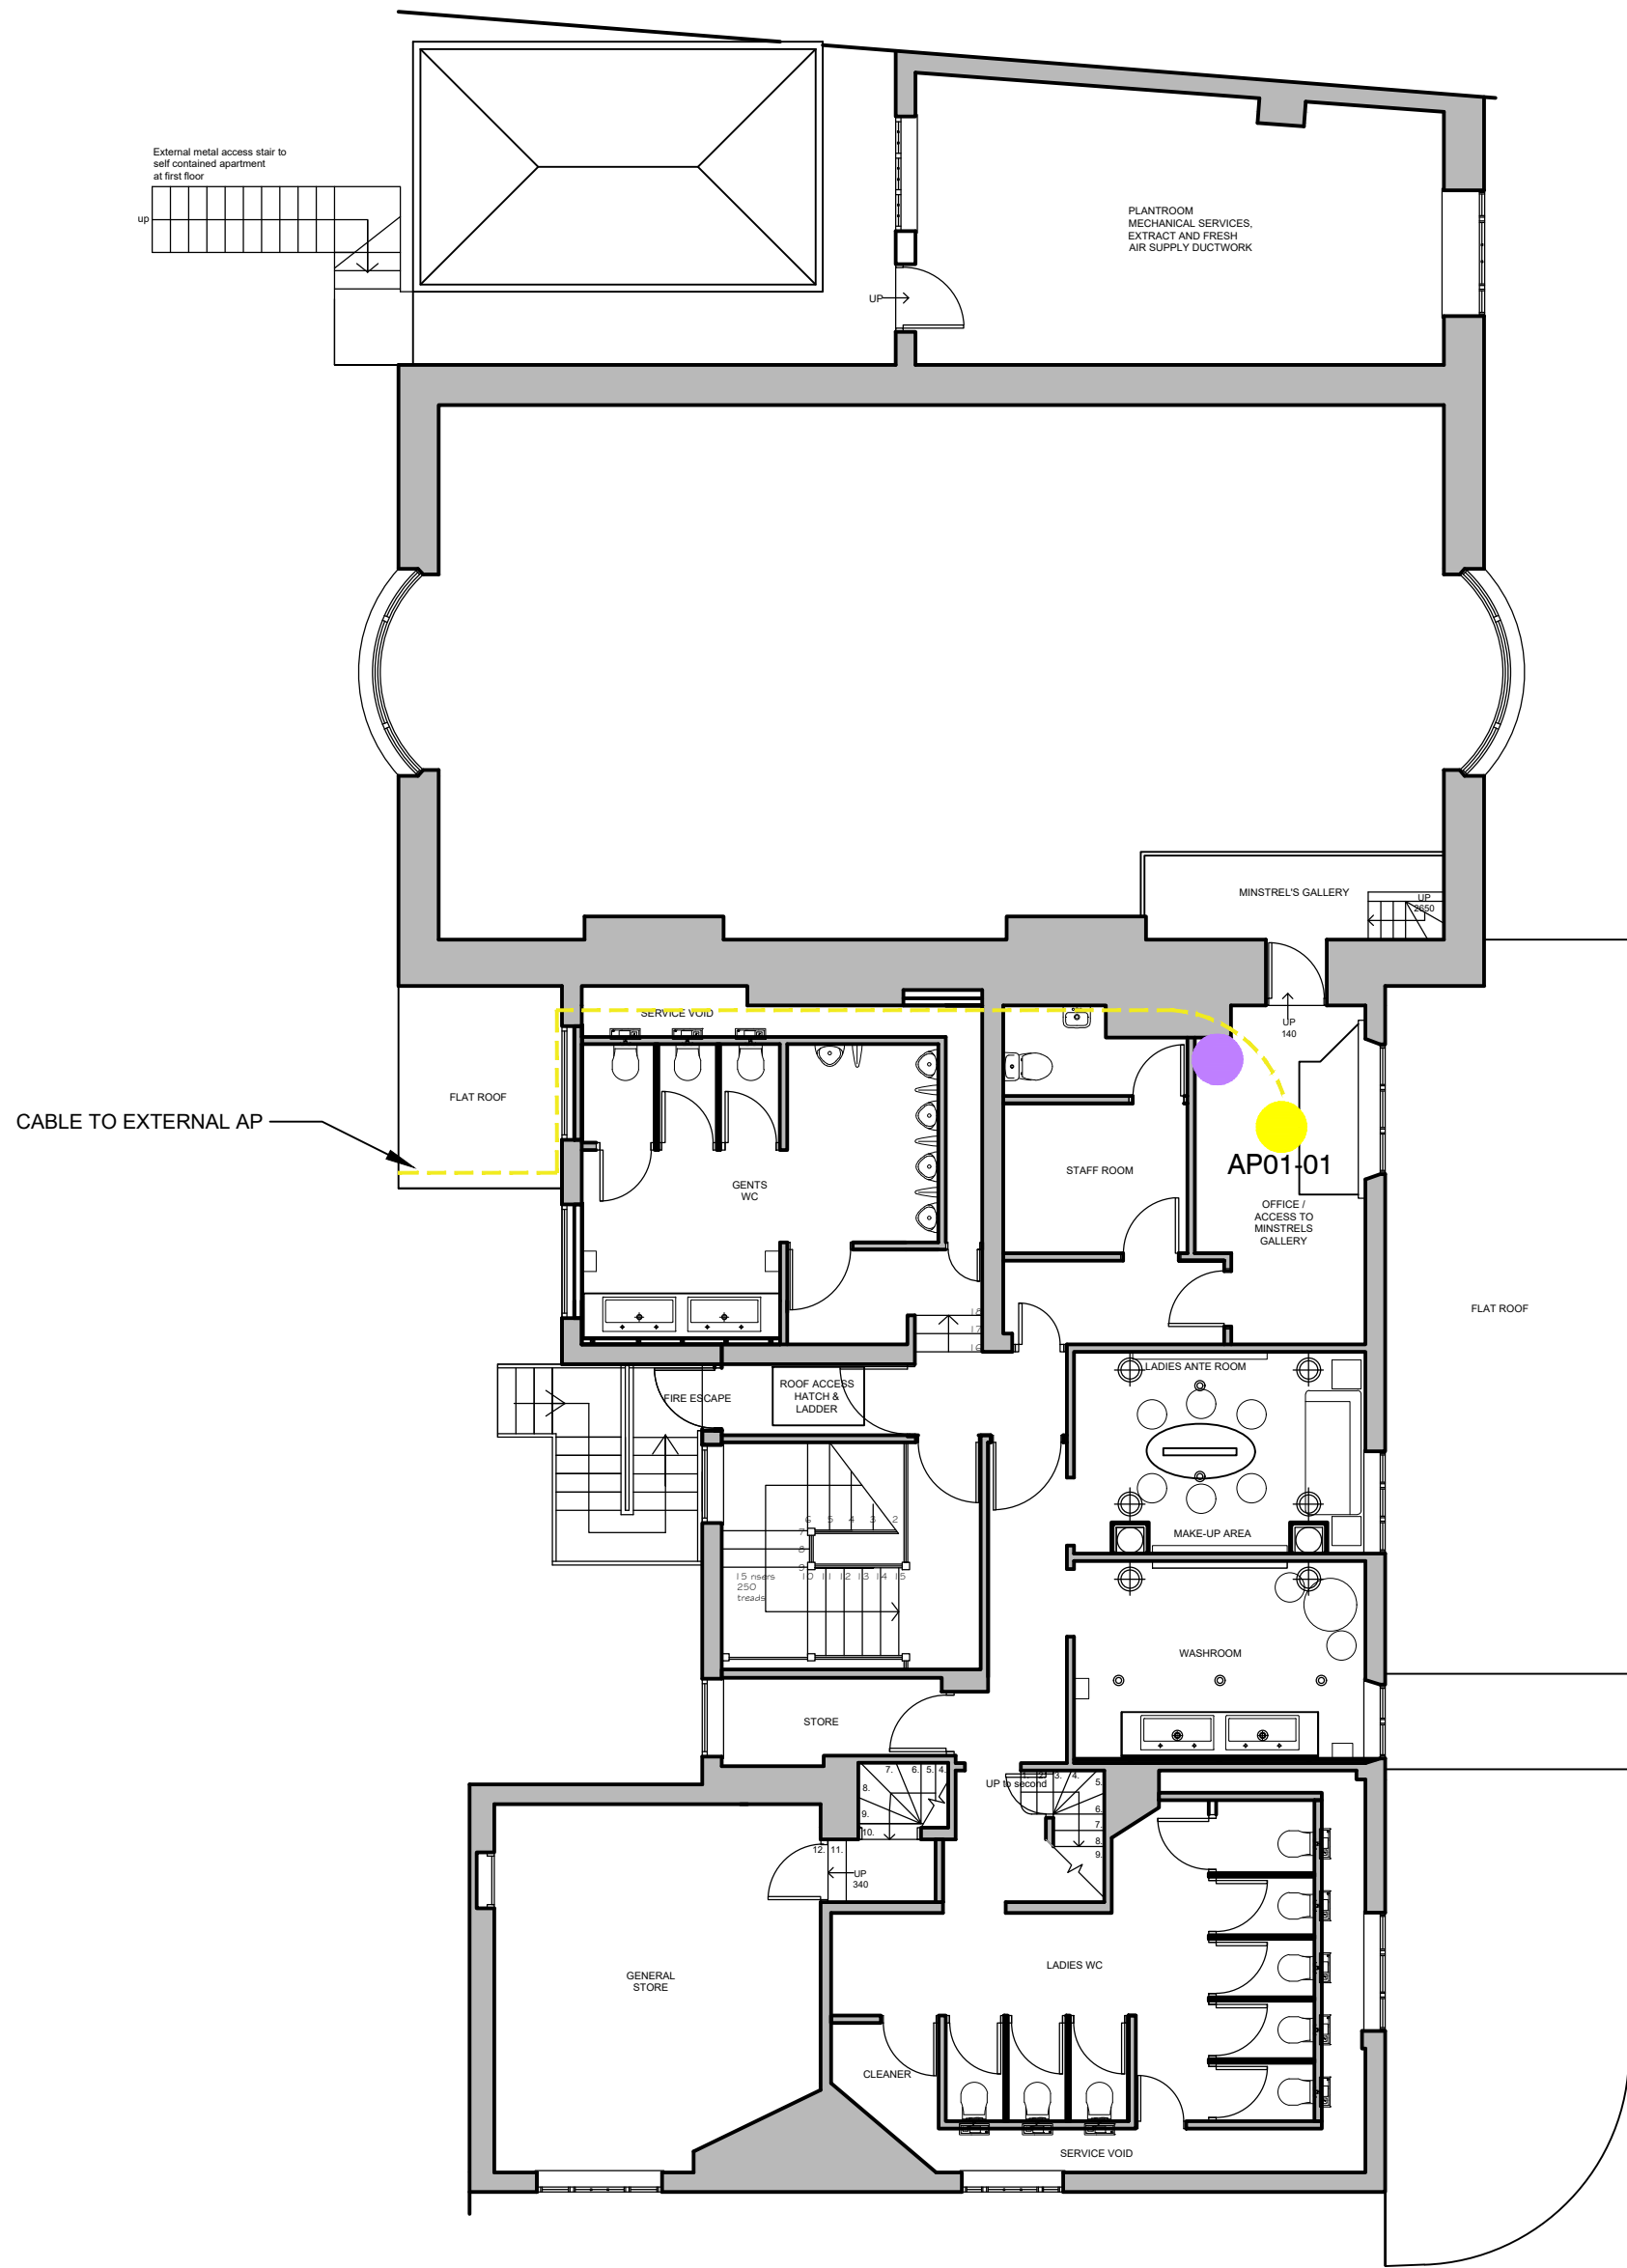

LEGEND

- CABLE ROUTE
- ADDITIONAL WIRELESS ACCESS POINTS
- EXISTING WIRELESS ACCESS POINTS
- WIRELESS ACCESS POINTS TO RELOCATE (PROPOSED LOCATION)
- WIRELESS ACCESS POINTS TO RELOCATE (EXISTING LOCATION)
- FORTINET 4G DEVICE

PROPOSED FIRST FLOOR PLAN
Scale 1:100

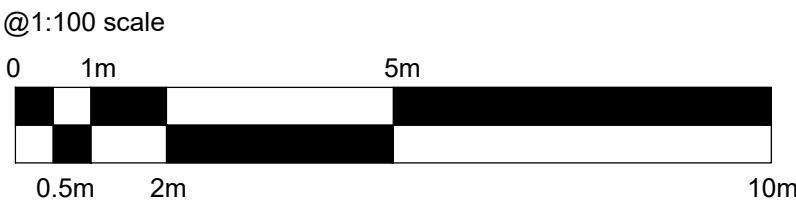

HARRISON INCE	
ARCHITECTS INTERIOR DESIGNERS	
JD WETHERSPOON	
CLIENT	
THE GREEN DRAGON, 2 ST EDWARD ST, LEEK, ST13 5DS	
PROJECT	
PROPOSED FIRST FLOOR PLAN	
TITLE	
DATE	APRIL 2025
SCALE	1:100 @ A1
JOB NO.	PN7029
DWG. NO.	AL02
DRAWN	CAD/FA
CHECKED	

SECOND FLOOR
EASTGATE
2 CASTLE STREET
MANCHESTER
M14 4LZ
TEL: 0161 226 3650
EMAIL: admin@harrisonince.co.uk