
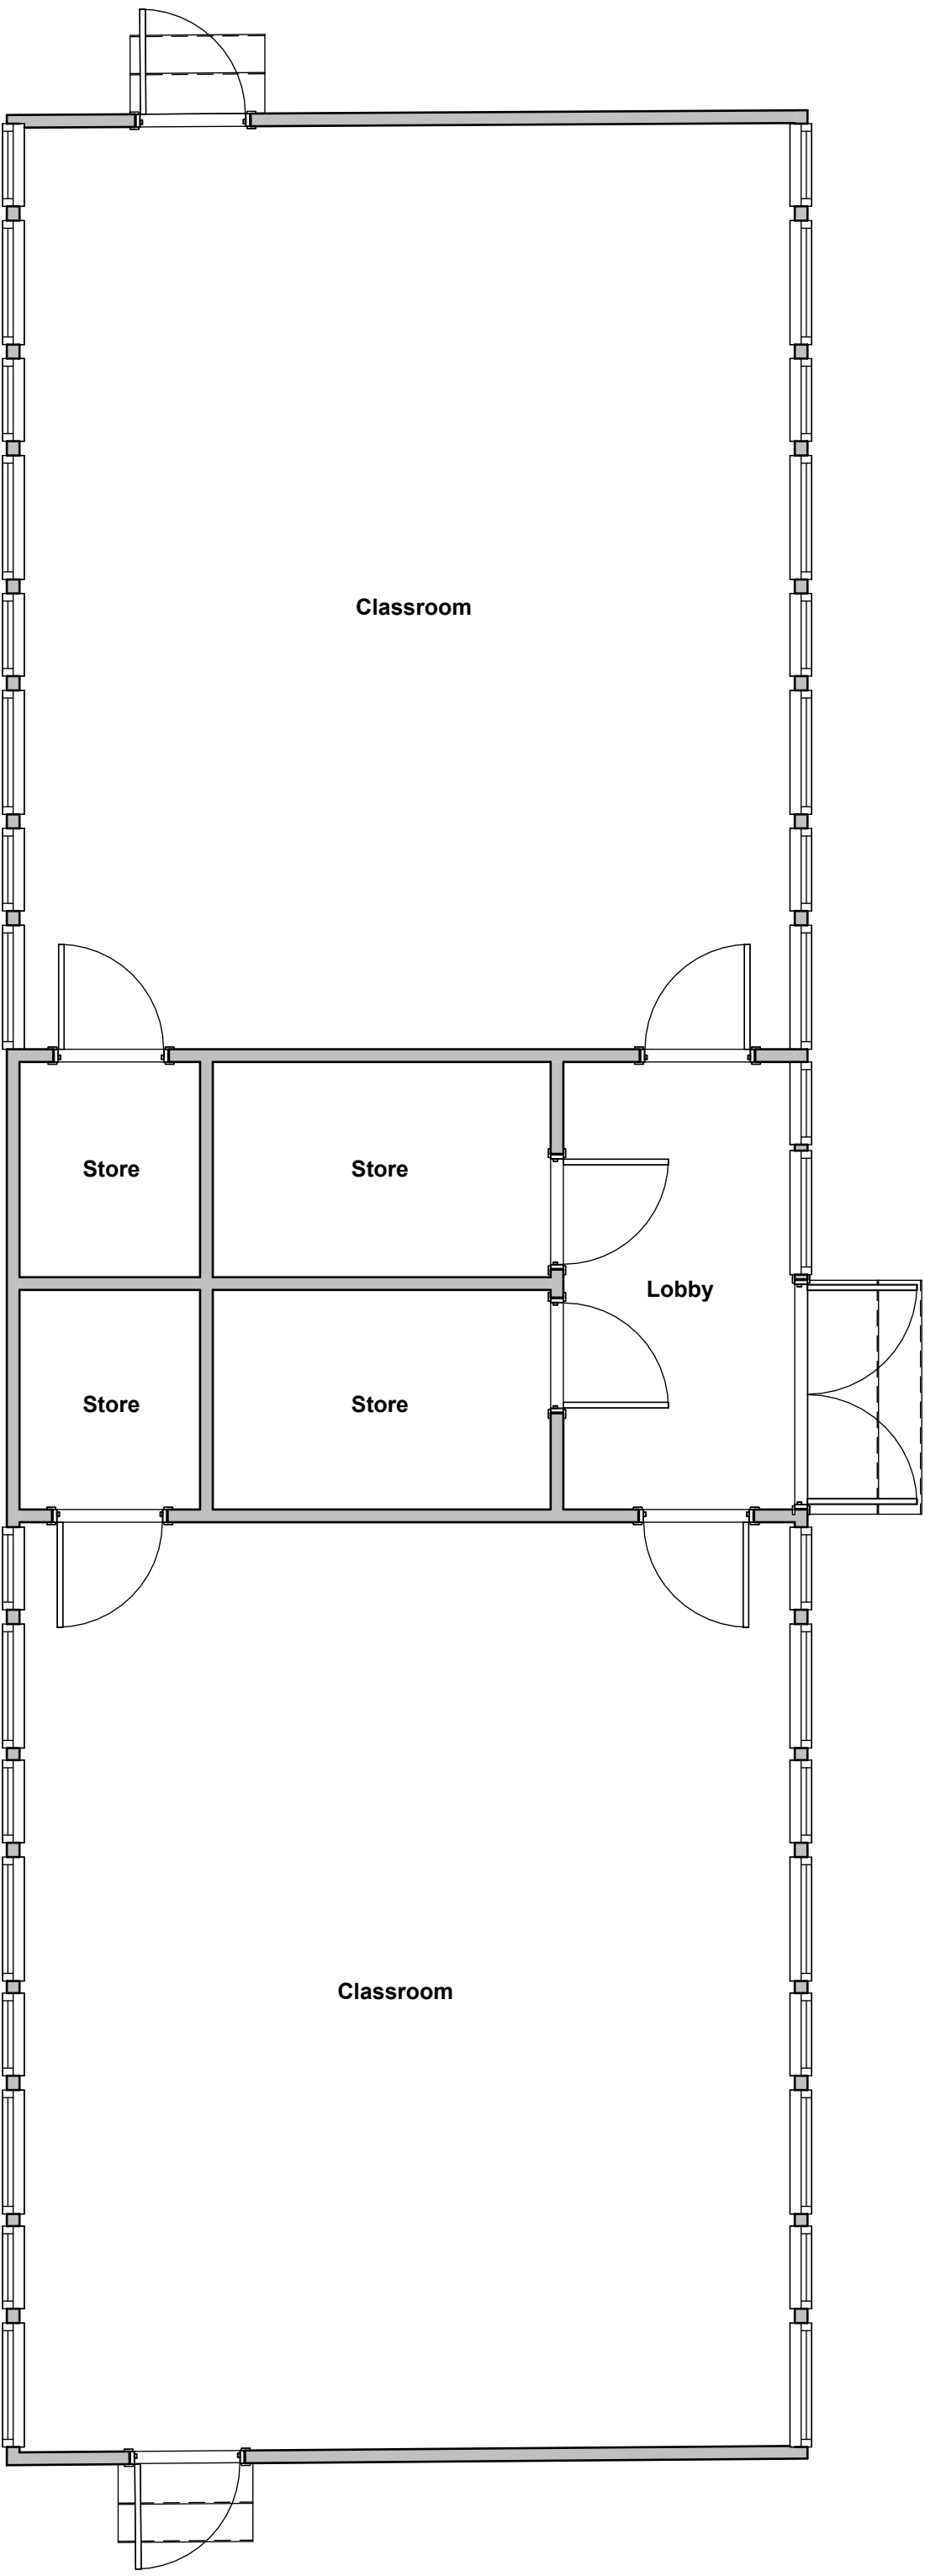


Notes

1. This drawing is subject to Copyright all rights reserved.
2. All existing dimensions should be checked on site before commencement of the work, any discrepancies to be reported to E3 Cube Ltd.
3. Figured dimensions are to be used in all case.

Emergency Lighting and Fire Alarm works to take place.

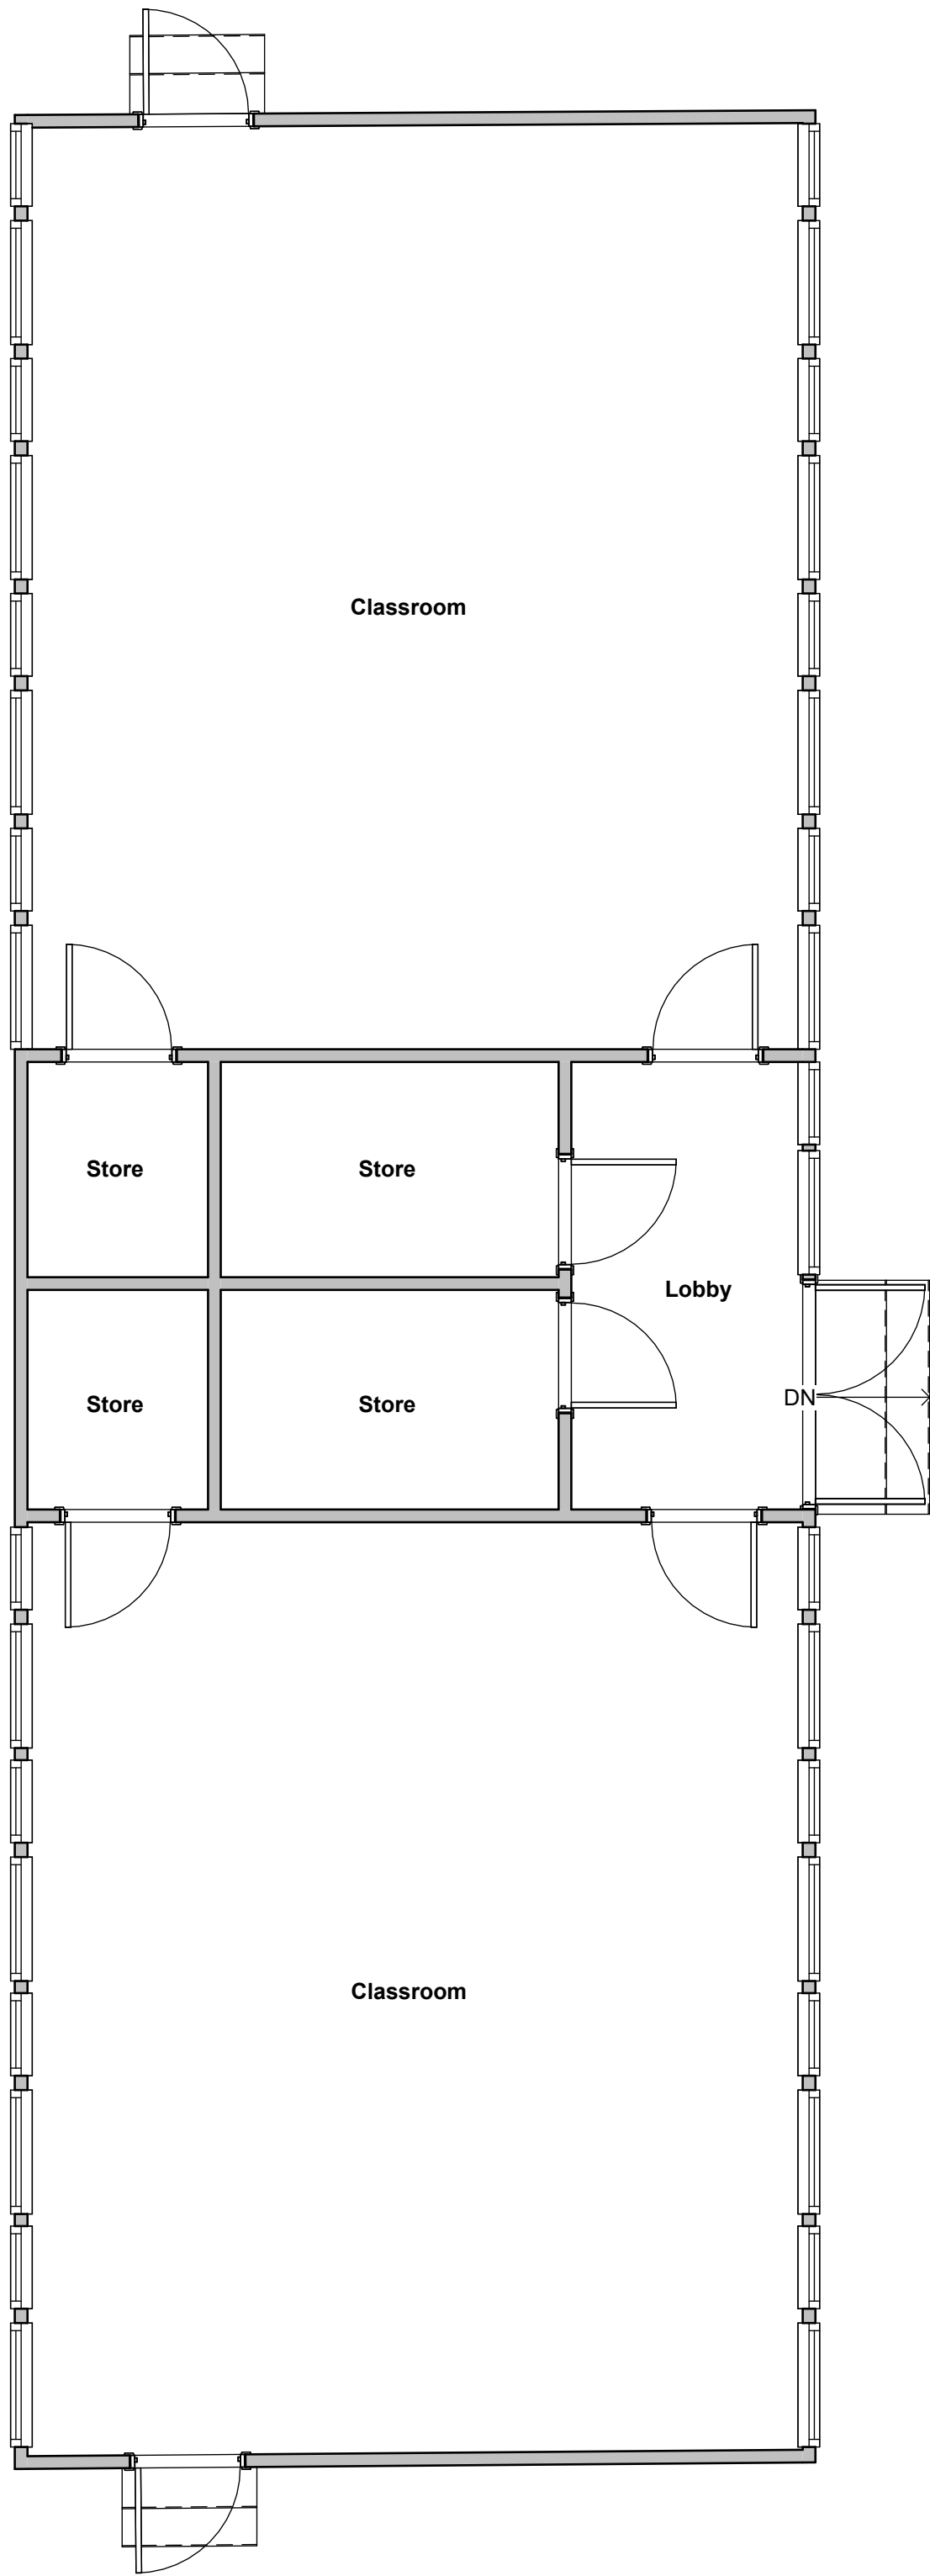

1 Existing Ground Floor

Scale 1 : 50

P02	Planning Issue.	10/06/2025
P01	PRELIMINARY - First Issue	15/05/2025
Rev.	Revision Description	Date
 E3 CUBE "Delivering Aspirations" Unit 23, Meridian Business Village, Harsby Drive, Liverpool, L24 9LG Tel +44 (0) 3333 058 291 www.e3cube.co.uk		
Client Talentum Learning Trust Westwood College, Westwood Park Dr, Leek, ST13 8NP		
Project Westwood College Fire Safety Works Westwood College, Westwood Park Dr, Leek, ST13 8NP		
Title Block E Existing Ground Floor Plan Modular Buildings 1 & 2		
Status Code - Purpose of Issue		Rev.
A3 - Planning Issue.		P02
E3C Job No.	Scale	Size
1748	1 : 50	@A1
Drawn	Checked	Approved
MA	PT	E3C
Drawing No. WST02F-E3C-11-00L-DR-B-001		
Project-Originator-Functional-Breakdown-Spatial-Breakdown-Form-Discipline-Number		

