

DRAINAGE DESIGN NOTES:

DRAINAGE DESIGN NOTES:

ROOF DRAINAGE TO UTILISE
4No. GUTTERS AND 2No DOWNPIPES AS INDICATED:

- 125mm GUTTERS
- Ø100mm DOWNPIPES

ALL BELOW GROUND DRAINAGE: 100% uPVC.

PROPOSED DISCHARGE INTO SOAKAWAY AS INDICATED ON DRAWING.



DRAINAGE PROPOSAL IN CONJUNCTION WITH NGED ST:EN2D/6.

KEY:

GY – GULLEY

MH – MANHOLE

RWP – RAIN WATER PIPE

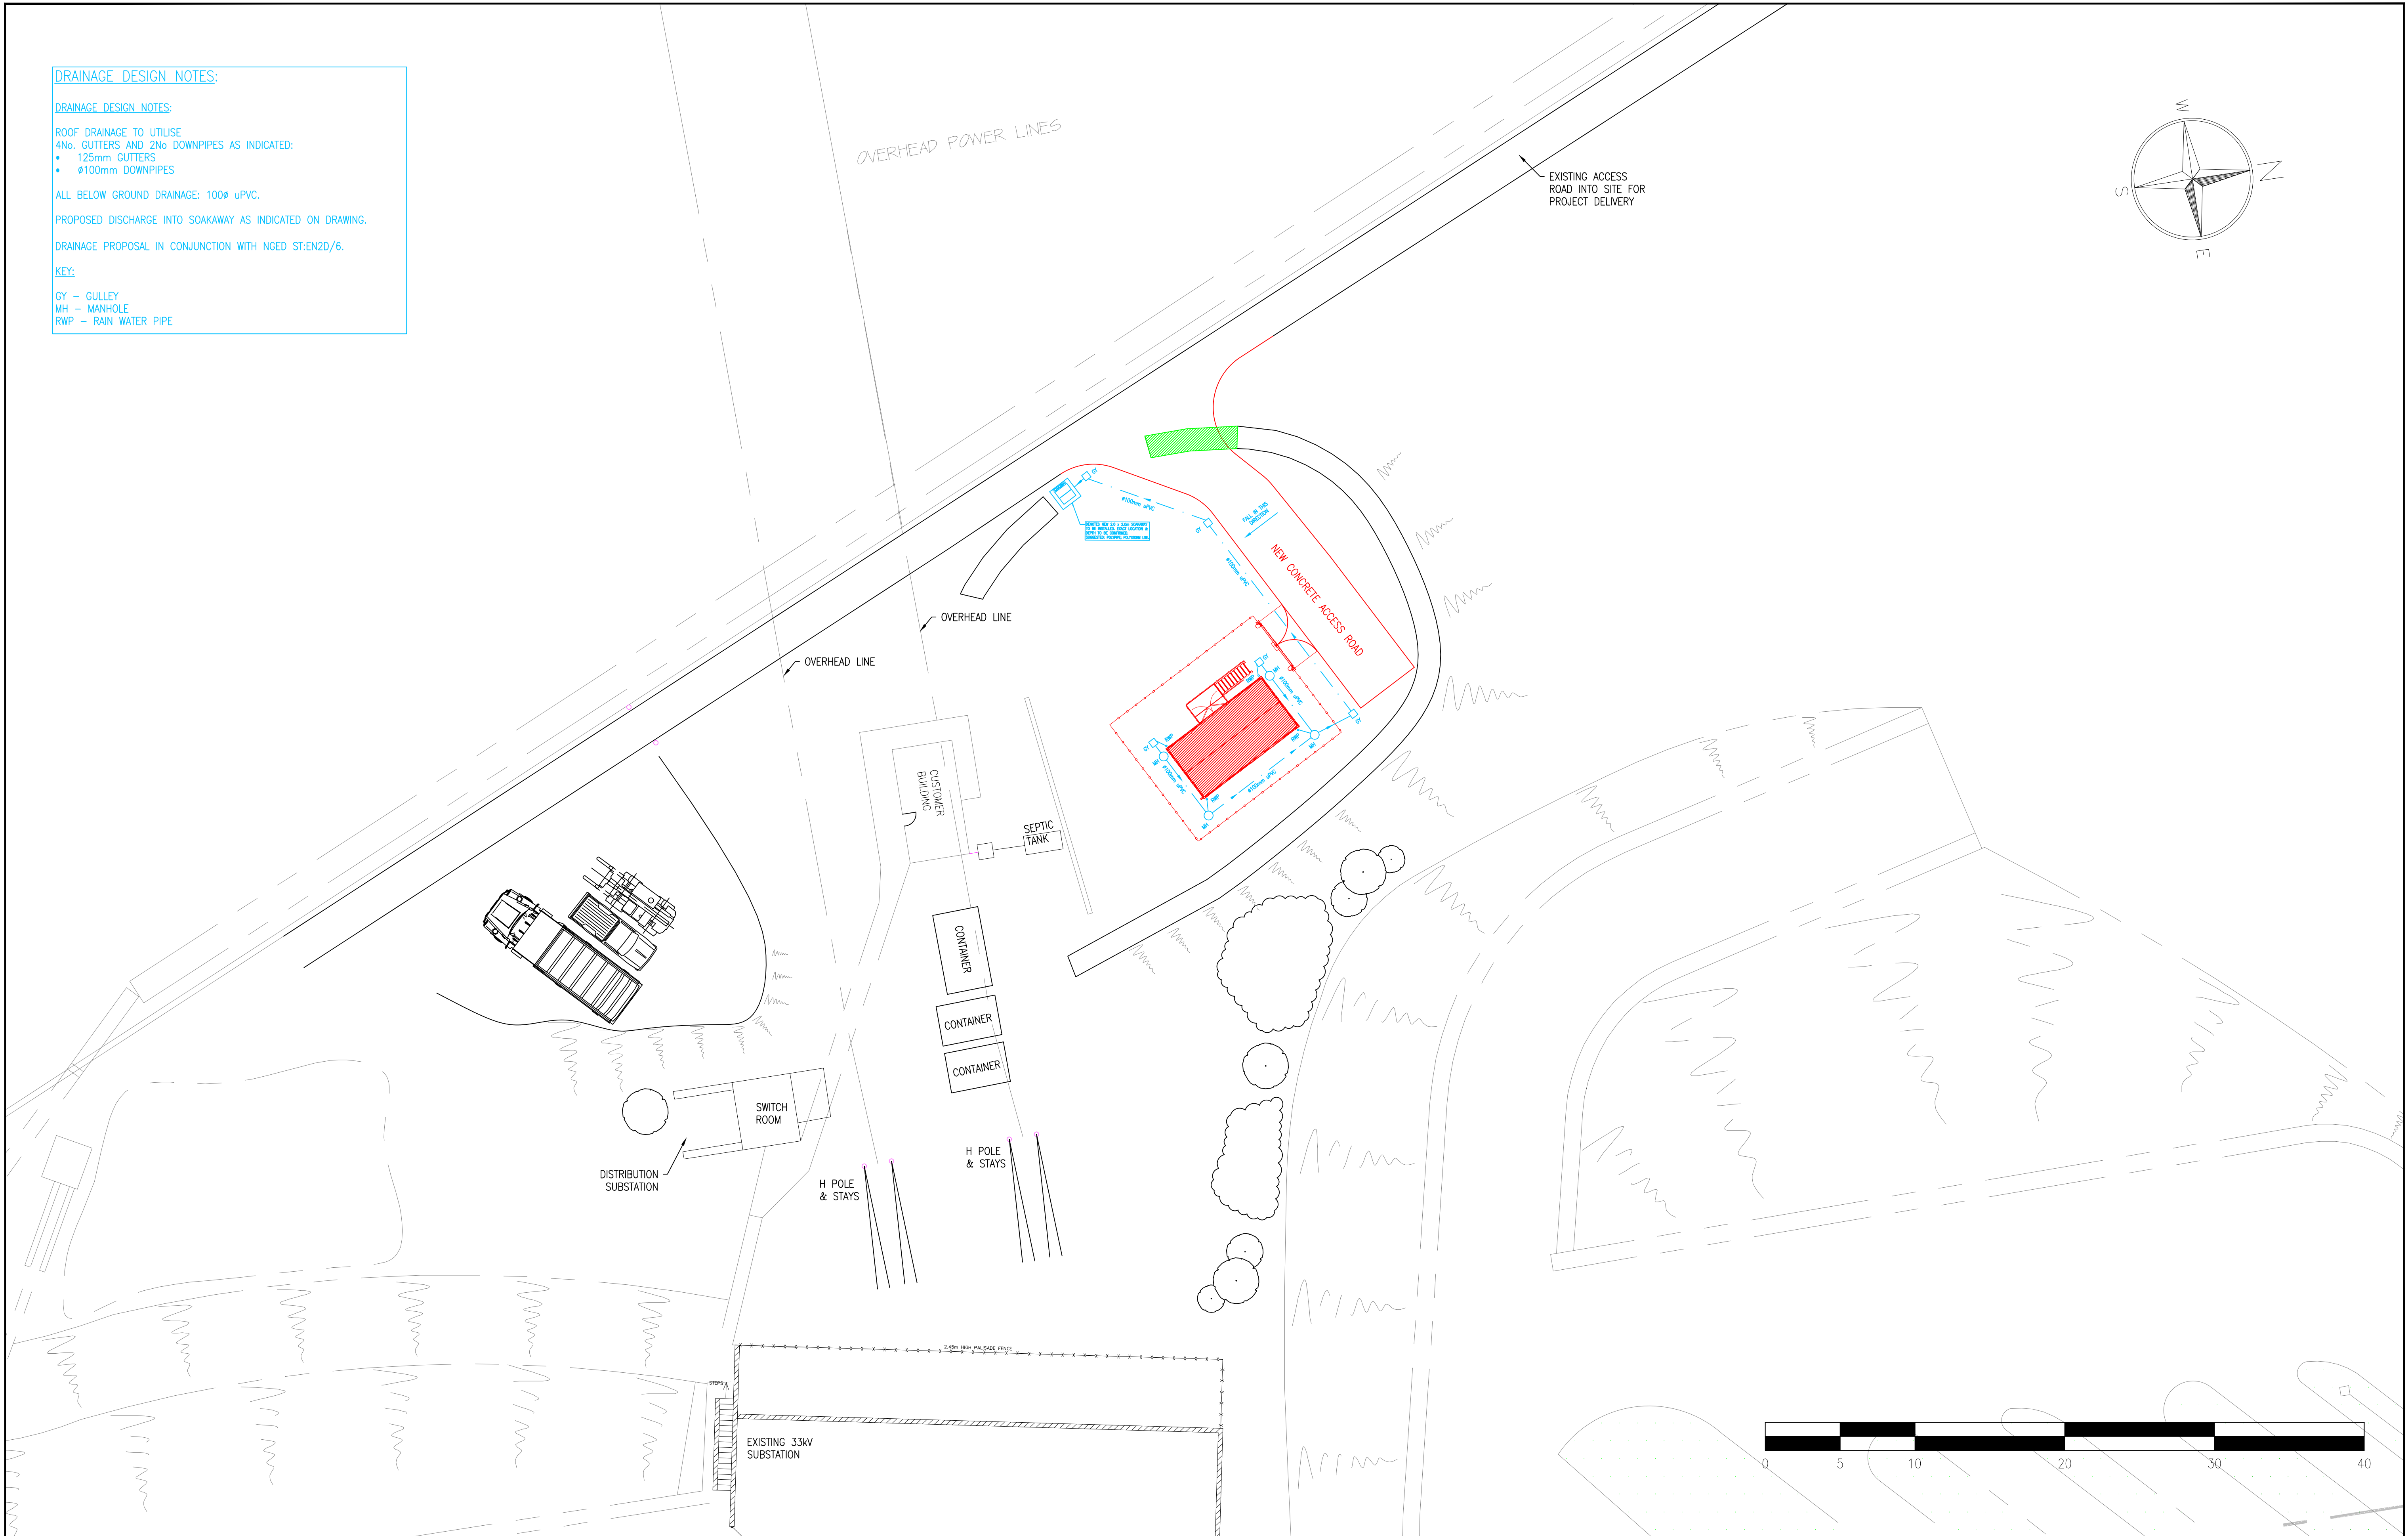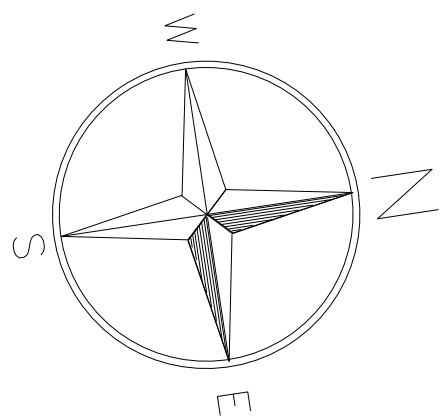

REV. 1	11/09/2025	REV. 2		REV. 3		REV. 4		REV. 5	
CHECKED	NGED_ED	CHECKED		CHECKED		CHECKED		CHECKED	
APPROVED	NGED_ED	APPROVED		APPROVED		APPROVED		APPROVED	
SOAKAWAY POSITION CHANGED.									

NOTES:

FOR PLANNING

DRAWN	RE	11/09/2025
CHECKED	NGED_ED	11/09/2025
APPROVED	NGED_ED	11/09/2025
SCALE	1:200 @ A1	
ALL RIGHTS ARE RESERVED TO NATIONAL GRID ELECTRICITY DISTRIBUTION (WEST MIDLANDS) plc. COMPANY NUMBER 03050574. NO PART OF THIS DRAWING MAY BE REPRODUCED OR TRANSMITTED IN ANY FORM OR BY ANY MEANS, INCLUDING PHOTOCOPYING AND RECORDING, OR STORED IN A RETRIEVAL SYSTEM OF ANY NATURE WITHOUT WRITTEN PERMISSION.		

CAULTON CEMENT 33/11kV SUBSTATION

PROPOSED DRAINAGE LAYOUT

nationalgrid		Electricity Distribution	
DRAWING No.	REV	SHEET	
NS17-102-008	1	1 of 1	